

LEE COUNTY UTILITIES CRYSTAL DRIVE WATER MAIN IMPROVEMENTS

10600 CHEVROLET WAY, SUITE 300
ESTERO, FL 33928
PHONE: 239.390.1467 FAX: 239.390.1769

www.tetratech.com



PROJECT LOCATION:

LEE COUNTY, FLORIDA

CLIENT INFORMATION:

LEE COUNTY UTILITIES
1500 MONROE ST.
FORT MYERS, FL 33901

Tt PROJECT No.:

200-01558-19001

CLIENT PROJECT No.:


PROJECT DESCRIPTION / NOTES:

16" WATER MAIN REPLACEMENT AND IMPROVEMENTS ALONG CRYSTAL DRIVE FROM BRANTLEY ROAD TO PLANTATION ROAD

ISSUED:

BID SET - 8-25-2020

VICINITY MAP:

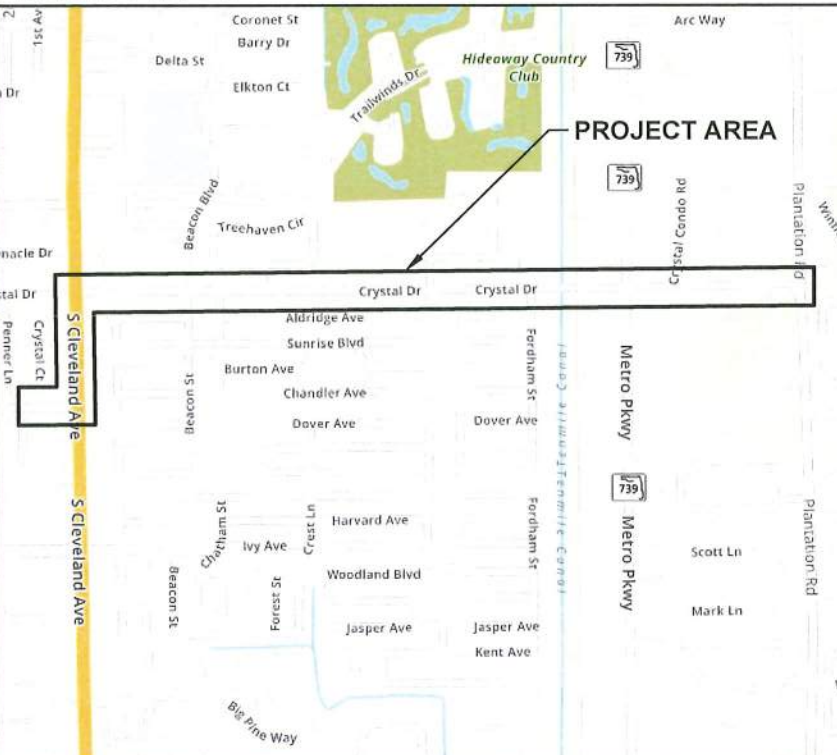

Steven J Agapi, P.E., State of Florida, Professional Engineer, License No. 88612

This item has been electronically signed and sealed by Steven J Agapi, P.E. on the date indicated here using a SHA authentication code.

Printed copies of this document are not considered signed and sealed and the SHA authentication code must be verified on any electronic copies.

PROJECT SITE

**Steven J
Agapi, P.E.
#88612**

Digitally signed
by Steven J
Agapi, P.E.
#88612
Date: 2020.08.25
14:59:55 -04'00'

PREPARED FOR
LEE COUNTY UTILITIES
1500 MONROE ST.
FORT MYERS, FLORIDA 33901
BOARD OF COUNTY COMMISSIONERS

JOHN MANNING
CECIL PENDERGRASS
RAY SANDELLI
BRIAN HAMMAN
FRANK MANN

PAMELA KEYES, PE

DISTRICT 1
DISTRICT 2
DISTRICT 3
DISTRICT 4 (CHAIRMAN)
DISTRICT 5 (VICE CHAIRMAN)

PUBLIC UTILITIES DIRECTOR



LEE COUNTY

STEVEN AGAPI, P.E.
LICENSE #88612
Tetra Tech Inc.
10600 Chevrolet Way, Ste. 102
Estero, Florida 33928
Engineering Business No. 2429

DATE _____



7/15/2020 6:50:46 PM - C:\PROJECTS\ORLANDO\OR01558\200-01558-19001\CAD\GENERAL NOTES & SHEET INDEX.DWG - CYR. STEVE

GENERAL NOTES

- ALL WORK SHALL CONFORM TO LATEST REVISION OF THE LCU DESIGN MANUAL WHICH IS AVAILABLE ON OUR WEB-PAGE VIA THE FOLLOWING LINK:
HTTPS://WWW.LEEGOV.COM/UTILITIES/DESIGN-MANUAL.
- ALL REGULATORY AND PERMITTING AGENCIES' REQUIREMENTS SHALL BE COMPLIED WITH AS WELL.
- ANY QUANTITIES SHOWN ON PLANS ARE NOT VERIFIED BY LCU.
- THE INFORMATION PROVIDED IN THESE PLANS IS SOLELY TO ASSIST THE CONTRACTOR IN ASSESSING THE NATURE AND EXTENT OF CONDITIONS THAT MAY BE ENCOUNTERED DURING THE COURSE OF WORK. ALL CONTRACTORS ARE DIRECTED, PRIOR TO BIDDING, TO CONDUCT WHATEVER INVESTIGATIONS THEY MAY DEEM NECESSARY TO ARRIVE AT THEIR OWN CONCLUSION REGARDING THE ACTUAL CONDITIONS THAT WILL BE ENCOUNTERED, AND UPON WHICH THEIR BIDS WILL BE BASED.
- ALL CONSTRUCTION WORK PERFORMED MUST BE DONE BY A CONTRACTOR LICENSED IN THE STATE OF FLORIDA TO DO THE WORK INTENDED.
- A PRE-CONSTRUCTION MEETING IS REQUIRED BEFORE WORK MAY BEGIN. REQUIRED ATTENDEES INCLUDE BUT ARE NOT LIMITED TO; THE ENGINEER OF RECORD OR HIS DESIGNEE, THE UNDERGROUND CONTRACTOR AND THE LCU INSPECTOR ASSIGNED TO THE PROJECT. LCU IS TO BE NOTIFIED TWO (2) WORKING DAYS PRIOR TO THE PRE-CONSTRUCTION MEETING.
- ONE COPY OF THE LCU APPROVED/STAMPED CONSTRUCTION PLANS, ALL CONTRACT DOCUMENTS, REFERENCE DOCUMENTS AND TECHNICAL DOCUMENTS SUBMITTED MUST BE KEPT AT THE SITE AND MAINTAINED IN GOOD ORDER.
- ALL WORK AND MATERIALS, WHICH DO NOT CONFORM TO LCU SPECIFICATIONS, ARE SUBJECT TO REMOVAL AND REPLACEMENT AT THE CONTRACTOR'S EXPENSE.
- ANY WORK PERFORMED WITHOUT THE KNOWLEDGE OF LCU IS SUBJECT TO RE-EXCAVATION, REMOVAL AND REPLACEMENT OF SAME TO BE DONE AT THE CONTRACTOR'S EXPENSE.
- LCU INSPECTION STAFF IS TO BE PRESENT FOR ALL HOT TAPS, PRESSURE TESTS AND FOR ANY NECESSARY INSPECTION. THE CONTRACTOR IS TO PROVIDE A MINIMUM OF TWO (2) WORKING DAYS NOTICE PRIOR TO SCHEDULING ANY OF THE ABOVE.
- TRAFFIC MUST BE MAINTAINED AT ALL TIMES AS PER LEE COUNTY DEPARTMENT OF TRANSPORTATION (LCDOT) AND PER FLORIDA DEPARTMENT OF TRANSPORTATION (FDOT) STANDARD SPECIFICATIONS FOR ROAD AND BRIDGE CONSTRUCTION, LATEST EDITION.
- THE CONTRACTOR IS TO UNCOVER ALL EXISTING LINES BEING TIED INTO AND VERIFY GRADES BEFORE BEGINNING CONSTRUCTION.
- LOCATIONS, ELEVATIONS, AND DIMENSIONS OF EXISTING UTILITIES, STRUCTURES AND OTHER FEATURES ARE SHOWN ACCORDING TO THE BEST INFORMATION AVAILABLE AT THE TIME OF PREPARATION OF THESE PLANS, BUT DO NOT PURPORT TO BE ABSOLUTELY CORRECT. LCU WILL NOT GUARANTEE ANY LOCATIONS AS SHOWN ON THESE PLANS OR THOSE OMITTED FROM THESE PLANS.
- THE CONTRACTOR SHALL VERIFY ALL UTILITIES AND PROVIDE AT LEAST TWO (2) WORKING DAYS NOTICE TO THE INDIVIDUAL UTILITY COMPANIES, FDOT AND LCDOT PRIOR TO CONSTRUCTION.
- IT IS THE CONTRACTOR'S RESPONSIBILITY TO LOCATE AND TAKE ALL POSSIBLE PRECAUTIONS TO AVOID ANY DAMAGE TO ALL UNDERGROUND PIPELINES, TELEPHONE, CABLE TV, ELECTRIC LINES/CONDUITS AND STRUCTURES IN ADVANCE OF ANY CONSTRUCTION. THE CONTRACTOR SHALL BE FULLY RESPONSIBLE FOR ANY AND ALL DAMAGES THAT MAY OCCUR DUE TO HIS FAILURE TO EXACTLY LOCATE AND PROTECT EXISTING UTILITIES AND STRUCTURES.
- ANYTHING NOT SHOWN ON THESE DRAWINGS SHOULD BE BROUGHT TO THE ATTENTION OF THE ENGINEER AND SHALL NOT CONSTITUTE AN EXTRA COST, UNLESS APPROVED BY THE ENGINEER OF RECORD.
- THE CONTRACTOR SHALL CONTACT THE ENGINEER AND LCU IMMEDIATELY CONCERNING ANY CONFLICTS WITH LCU UTILITIES/STRUCTURES ARISING DURING CONSTRUCTION OF ANY FACILITIES SHOWN ON THESE DRAWINGS.
- THE CONTRACTOR SHALL VERIFY ALL QUANTITIES SHOWN ON THE PLANS. IF ANY DISCREPANCIES IN QUANTITIES ARE FOUND, THE CONTRACTOR SHALL NOTIFY THE ENGINEER OF RECORD AND LCU.
- THE CONTRACTOR SHALL REPLACE ALL PAVEMENT, CURBS, DRIVEWAYS, SIDEWALKS, FENCES, ETC., WITH THE SAME TYPE OF MATERIAL THAT WAS REMOVED DURING CONSTRUCTION OR AS DIRECTED BY THE ENGINEER. THE CONTRACTOR SHALL RESTORE ALL AREAS AFFECTED BY THE CONSTRUCTION TO ITS ORIGINAL CONDITION, OR BETTER. THE CONTRACTOR SHALL PROTECT ALL EXISTING SIDEWALKS, PAVEMENT, CURBS AND DRIVEWAYS NOT SHOWN TO BE REPLACED IN THE DRAWINGS. THE CONTRACTOR SHALL REPLACE ALL DAMAGED SIDEWALKS, PAVEMENT, CURBS AND DRIVEWAYS NOT PLANNED FOR REMOVAL OR REPLACEMENT AT THEIR OWN COST.
- ALL FRAMES, COVERS VALVE BOXES, METER BOXES AND MANHOLES SHALL BE ADJUSTED TO FINISHED GRADE UPON COMPLETION OF PAVING OR RELATED CONSTRUCTION. ALL VALVE PADS SHALL BE POURED IN PLACE. NO PRE-FORMED VALVE PADS WILL BE ALLOWED.

GENERAL NOTES

- APPROPRIATE TURBIDITY CONTROL DEVICES (E.G. SILT FENCES, HAY BALES) WILL BE UTILIZED DURING ALL PHASES OF INSTALLATION AND GRADING. CONTRACTOR IS RESPONSIBLE FOR SUBMITTING THE NOTICE OF INTENT AND NOTICE OF TERMINATION TO THE EPA IN COMPLIANCE WITH LEE COUNTY'S NPDES PERMIT.
- CONTRACTOR IS RESPONSIBLE FOR DEVELOPING AND MAINTAINING AN EFFECTIVE STORM WATER POLLUTION PREVENTION PLAN.
- LCU REQUIRES 30" OF COVER FOR ALL UNDERGROUND PIPING EXCEPT UNDER PAVEMENT, WHERE 36" OF COVER IS REQUIRED. IF LCU REQUIRED COVER CANNOT BE MAINTAINED, THE CONTRACTOR SHALL PROVIDE OTHER METHODS OF CONSTRUCTION OR PIPE PROTECTION, WHICH SHALL FIRST BE APPROVED BY LCU AND THE ENGINEER, AT NO ADDITIONAL COST TO THE COUNTY. IF STATE AGENCIES REQUIRE ADDITIONAL COVER, MEETING THE REQUIREMENTS SHALL BE DONE AT NO ADDITIONAL COST TO THE COUNTY.
- LCU REQUIRES THERE TO BE A MINIMUM OF TEN (10) FEET HORIZONTAL AND 18" VERTICAL SEPARATION BETWEEN POTABLE WATER & SANITARY SEWER MAINS. LCU ALSO REQUIRES MINIMUM OF TEN (10) FEET HORIZONTAL SEPARATION BETWEEN OTHER PUBLIC AND/OR PRIVATE UTILITIES, STRUCTURE(S), BUILDING(S), WALL(S), FOUNTAIN(S), FENCE(S) AND LCU INFRASTRUCTURE UNLESS SPECIFICALLY APPROVED BY LCU.
- LCU REQUIRES THERE TO BE A MINIMUM OF FIVE (5) FEET HORIZONTAL SEPARATION BETWEEN LCU INFRASTRUCTURE AND DRAINAGE INFRASTRUCTURE, MITERED END SECTIONS, INLETS, ETC. LCU ALSO REQUIRE MINIMUM OF FIVE (5) FEET HORIZONTAL SEPARATION BETWEEN LCU INFRASTRUCTURE AND ALL NEW LIGHT POLE FOUNDATIONS.
- THE ROOT BALL OF PALM TREES SHALL BE A MINIMUM OF FIVE (5) FEET AND THE ROOT BALL OF SHADE TREES SHALL BE A MINIMUM OF TEN (10) FEET FROM ANY EXISTING OR PROPOSED LCU OWNED AND MAINTAINED PIPE/INFRASTRUCTURE.
- AS THE WORK PROGRESSES THE CONTRACTOR SHALL RECORD ALL CHANGES AND DEVIATIONS FROM THE LCU STAMPED/APPROVED CONSTRUCTION PLANS. IN ADDITION, HE SHALL RECORD THE EXACT LOCATION OF ALL CHANGES IN VERTICAL AND HORIZONTAL ALIGNMENT WITH COORDINATES WITH RESPECT TO THE NAVD 1988 STATE PLANE FLORIDA WEST COORDINATE SYSTEM AS WELL AS ALL REQUIREMENTS SET FORTH IN THE LCU DESIGN MANUAL. THIS INFORMATION IS TO BE FORWARDED TO THE ENGINEER OF RECORD WHO PREPARED, SIGNED AND SEALED APPROVED CONSTRUCTION PLANS SO THAT HE CAN PREPARE 'RECORD DRAWINGS' PER THE REQUIREMENTS SET FORTH IN THE LCU DESIGN MANUAL.
- EXISTING SUBSURFACE UTILITY HORIZONTAL AND VERTICAL ALIGNMENTS WERE ESTABLISHED THROUGH THE USE OF AVAILABLE RECORDS AND, THEREFORE, ARE SHOWN IN APPROXIMATE LOCATIONS. THE CONTRACTOR SHALL NOTIFY THE RESPECTIVE UTILITY COMPANIES NO LATER THAN 48 HOURS PRIOR TO COMMENCING WORK IN A SPECIFIC AREA. THE CONTRACTOR SHALL BE RESPONSIBLE FOR THE VERIFICATION OF ALL UTILITIES SIZE AND LOCATIONS.
- BURIED PHONE LINES EXIST THROUGHOUT THE LIMITS OF WORK BUT MAY NOT BE IDENTIFIED ON THE DRAWINGS. PROCEED WITH CAUTION TO MAINTAIN THE PHONE SERVICES. DAMAGES TO, OR RELOCATION OF PHONE LINES DURING CONSTRUCTION SHALL BE REPORTED IMMEDIATELY TO AND/OR COORDINATED WITH THE SERVICE PROVIDER AND REPAIRED OR RELOCATED AT THE CONTRACTOR'S EXPENSE.
- WATER, SEWER, AND IRRIGATION SERVICES MAY EXIST WITHIN THE LIMITS OF WORK BUT MAY NOT BE IDENTIFIED ON THE DRAWINGS. PROCEED WITH CAUTION TO MAINTAIN ALL SERVICES. DAMAGES TO, OR RELOCATION OF SERVICES DURING CONSTRUCTION SHALL BE REPORTED IMMEDIATELY TO AND/OR COORDINATED WITH LEE COUNTY UTILITIES AND REPAIRED OR RELOCATED AT THE CONTRACTOR'S EXPENSE.
- OVERHEAD AND UNDERGROUND ELECTRIC LINES EXIST THROUGHOUT THE LIMITS OF WORK BUT MAY NOT BE SHOWN ON THE DRAWINGS. PROCEED WITH CAUTION TO PROTECT THE ELECTRIC LINES AND POLES. DAMAGES TO, OR RELOCATION OF ELECTRIC LINES OR POLES SHALL BE REPORTED IMMEDIATELY TO AND/OR COORDINATED WITH POWER COMPANY AND REPAIRED OR RELOCATED AT THE CONTRACTOR'S EXPENSE. THE CONTRACTOR SHALL ARRANGE AND PAY FOR ALL UTILITY POLE BRACING REQUIRED BY HIS OPERATIONS.
- BURIED CABLE AND FIBER OPTIC LINES EXIST THROUGHOUT THE LIMITS OF WORK BUT MAY NOT BE SHOWN ON THE DRAWINGS. PROCEED WITH CAUTION TO PROTECT THE BURIED CABLE AND FIBER OPTIC LINES. DAMAGES TO OR RELOCATION OF CABLE AND FIBER OPTIC LINES SHALL BE REPORTED IMMEDIATELY TO AND/OR COORDINATED WITH THE RESPECTIVE UTILITY AND REPAIRED OR RELOCATED AT THE CONTRACTOR'S EXPENSE.
- CONTRACTOR SHALL EXCAVATE TEST PITS FOR THE PURPOSE OF PROTECTING AND CONFIRMING LOCATION AND DEPTH OF EXISTING UTILITIES OR STRUCTURES IN ADVANCE OF CONSTRUCTION. TEST PITS SHALL BE DUG BY HAND OR SOFT DIG METHOD AND BACKFILLED IMMEDIATELY AFTER THEIR PURPOSE HAS BEEN SATISFIED AND SHALL NOT REMAIN OPEN DURING NONWORKING HOURS.
- CONTRACTOR SHALL ENSURE THAT PEAK PARTICLE VELOCITY AS MEASURED BY A GEOPHONE, SEISMOGRAPH, OR OTHER APPROPRIATE DEVICE DOES NOT EXCEED 0.5 INCHES PER SECOND AS MEASURED AT THE RIGHT-OF-WAY LINE DURING ROCK EXCAVATION AND COMPACTION. CONTRACTOR SHALL BE RESPONSIBLE FOR PROVIDING, MONITORING, CALIBRATING, AND MAINTAINING ALL VIBRATION MONITORING EQUIPMENT. IF AT ANY TIME THE PEAK PARTICLE VELOCITY EXCEEDS 0.5 INCHES PER SECOND THEN THE CONTRACTOR SHALL MODIFY HIS CONSTRUCTION OPERATIONS AS NECESSARY, INCLUDING BUT NOT LIMITED TO USING STATIC COMPACTION METHODS IN LIEU OF VIBRATORY ROLLERS.

GENERAL NOTES

- CONTRACTOR TO CONDUCT PRE CONSTRUCTION PHOTO/VIDEO SURVEY OF STRUCTURES ON CRYSTAL DRIVE. CONTRACTOR TO MONITOR VIBRATION CAUSED BY CONSTRUCTION ACTIVITIES AND TAKE PROPER MEASURES TO MITIGATE DAMAGE TO ALL STRUCTURES. ALL COSTS ASSOCIATED WITH DAMAGE TO STRUCTURES CAUSED BY THE CONTRACTOR AND/OR CONSTRUCTION ACTIVITIES WILL BE PAID FOR BY THE CONTRACTOR AT NO COST TO THE COUNTY.
- DEPTHS OF SANITARY SEWER MAINS AND MANHOLES WERE DERIVED FROM GIS, RECORD DRAWINGS, AND OTHER SOURCES. CONTRACTOR IS HEREBY ADVISED THAT PRIOR TO CONSTRUCTION, DEPTHS SHALL BE FIELD VERIFIED AND ANY POTENTIAL CONFLICTS SHALL BE BROUGHT TO THE ATTENTION OF THE ENGINEER AND LEE COUNTY PRIOR TO PROCEEDING. CONTRACTOR IS HEREBY ADVISED THAT THE PROPOSED DEPTH OF THE WATER MAIN MAY NEED TO BE ADJUSTED DURING CONSTRUCTION. IT SHALL BE THE CONTRACTOR'S RESPONSIBILITY TO VERIFY AND CONFIRM THAT ALL MINIMUM SEPARATION REQUIREMENTS ARE MAINTAINED.
- CONTRACTOR TO FIELD VERIFY ALL EXISTING UTILITIES PRIOR TO CONSTRUCTION, ANY POTENTIAL CONFLICTS SHALL BE BROUGHT TO THE ATTENTION OF THE ENGINEER AND LEE COUNTY PRIOR TO PROCEEDING.
- TREES AND BUSHES SHOWN WERE DERIVED FROM GIS AND AERIAL SOURCES AND ARE PROVIDED FOR INFORMATIONAL PURPOSES ONLY.
- CONTRACTOR MUST UTILIZE AN ARBORIST WHO IS CAPABLE IN EVALUATING OAK TREES THROUGHOUT THE PROJECT AND PROVIDE TRIMMING SERVICES AS NEEDED TO MITIGATE DAMAGE TO TREES. IF ANY PROPOSED WORK IS FOUND BY THE ARBORIST TO POTENTIALLY CAUSE DEATH OR SEVERE DAMAGE TO OAK TREES, THE CONTRACTOR MUST BRING THE CONFLICT TO THE ATTENTION OF THE COUNTY AND ENGINEER FOR FINAL DECISION.
- DRIVEWAY CULVERT END TREATMENTS IN CONFLICT WITH THE PROPOSED WATER MAIN SHALL BE REMOVED AND REPLACED WITH CONCRETE MITERED END SECTIONS AS SHOWN ON THE DETAIL SHEETS HEREIN.

SURVEY NOTES

- DATE OF LAST FIELDWORK: APRIL 6, 2020.
- COORDINATES AND HORIZONTAL DATA SHOWN HEREON AND IN AUTOCAD FILE ARE IN FEET AND ARE PROJECTED ONTO THE FLORIDA STATE PLANE COORDINATE SYSTEM, WEST ZONE, NORTH AMERICAN DATUM OF 1983 (NAD83), 2011 ADJUSTMENT.
- VERTICAL DATA (ELEVATIONS) SHOWN HEREON ARE IN FEET AND ARE REFERENCED TO THE NORTH AMERICAN VERTICAL DATUM OF 1988 (NAVD88). THE REFERENCE BENCHMARK IS FDOT BM 197 FOR FINANCIAL PROJECT ID 416519-1 (STATE RD 45, CLEVELAND AVENUE) WITH A PUBLISHED ELEVATION OF 11.119 FEET (NGVD29) AND CONVERTED TO THE NORTH AMERICAN VERTICAL DATUM OF 1988 (NAVD88) USING A CONVERSION FACTOR OF -1.18 FEET FOR AN ELEVATION OF 9.94 (NAVD88).
- SURVEYED AREA IS IN F.E.M.A. FLOOD ZONE X (AREAS DETERMINED TO BE OUTSIDE THE 0.2% ANNUAL CHANCE FLOOD PLANE, NO BASE FLOOD ELEVATION DETERMINED) AS SHOWN ON THE NATIONAL FLOOD INSURANCE PROGRAM'S DIGITAL FLOOD INSURANCE RATE MAP (D.F.I.R.M.) COMMUNITY PANEL NUMBER 12070C0428G, EFFECTIVE DATE: DECEMBER 7, 2018.
- SUBSTANTIAL VISIBLE IMPROVEMENTS OTHER THAN THOSE SHOWN, NOT LOCATED. UNDERGROUND IMPROVEMENTS AND/OR ENCROACHMENTS WERE NOT LOCATED AS A PART OF THIS SURVEY.
- THIS SURVEY IS SUBJECT TO ANY FACTS THAT MAY BE DISCLOSED BY A FULL AND ACCURATE TITLE SEARCH. A TITLE COMMITMENT AND/OR ABSTRACT OF TITLE WAS NOT PROVIDED TO THE SURVEYOR.
- THIS SURVEY DOES NOT MAKE ANY REPRESENTATION AS TO ZONING OR DEVELOPMENT RESTRICTIONS.
- NO ENVIRONMENTAL ASSESSMENT OR AUDIT WAS PERFORMED ON THE SURVEYED AREA BY THIS FIRM. THIS SURVEY WAS PERFORMED FOR THE PURPOSE SHOWN HEREON AND DOES NOT MAKE ANY REPRESENTATION AS TO THE DELINEATION OF ANY JURISDICTIONAL LINES EXCEPT AS SHOWN OR NOTED. THIS SURVEY DOES NOT PURPORT TO DELINEATE THE REGULATORY JURISDICTION OF ANY FEDERAL, STATE OR LOCAL AGENCY.
- THIS SURVEY DOES NOT DETERMINE PROPERTY OWNERSHIP OR PROPERTY RIGHTS. THIS SURVEY LOCATED THE BOUNDARY IN ACCORDANCE WITH AND IN RELATION TO THE LEGAL DESCRIPTION.
- AERIAL PHOTOGRAPHY SHOWN HEREON WAS OBTAINED FROM LABINS (LAND BOUNDARY INFORMATION SYSTEM) AND IS DATED 2017. IT IS INCLUDED FOR ORIENTATION PURPOSES ONLY.

PIPING MATERIAL SCHEDULE

MARK	SERVICE	BURIED PIPE			BURIED FITTINGS	
		MATERIAL	CLASS	LINING	MATERIAL	LINING
PW	POTABLE (≥ 10")	DI	PC 250	CEMENT	DI	CEMENT
PW	POTABLE (< 10")	DI	DR 18	NA	DI	CEMENT
PW	POTABLE (DIRECTIONAL DRILLS)	HDPE	DR11	NA	DI	CEMENT
PW	POTABLE CASING FOR HDD	HDPE	DR 13.5	NA	DI	CEMENT



STEVEN AGAPI, P.E.
LICENSE #69812
Tetra Tech Inc.
10600 Chevrolet Way, Ste. 102
Estero, Florida 33928
Engineering Business No. 2429

10600 CHEVROLET WAY, SUITE 102
ESTERO, FL 33928
PHONE: (239) 390-1467 FAX: (407) 835-3790

DATE _____

LEE COUNTY UTILITIES
CRYSTAL DRIVE
WATER MAIN IMPROVEMENTS
GENERAL NOTES

Project No.: 200-01558-19001
Designed By: AS
Drawn By: WV
Checked By: AS

G-001

APP	ALARM ANNUNCIATOR PANEL	EFF	EFFLUENT	M	METER
ARV	AUTOMATIC AIR RELEASE	E/L	EASEMENT LINE	MT	
	VALVE	EL	ELEVATION	MAINT	MAINTAIN OR MAINTENANCE
AAV	AUTOMATIC AIR VENT	ELEC	ELECTRICAL	MAN	MANUALLY
AB	ANCHOR BOLT	EM	ELECTRIC METER	MAS	MASONRY
ABAN	ABANDONED	EMER	EMERGENCY	MATL	MATERIAL
ABV	ABOVE	EMC	ENCASE(MENT)	MAX	MAXIMUM
AC	ALTERNATING CURRENT	ENGR	ENGINEER	MB	MAILBOX
ACCP	ANTHRA-COATED	EP	EDGE OF PAVEMENT	MCC	MOTOR CONTROL CENTER
	CORRUGATED METAL PIPE	EPRF	EXPLOSION PROOF	ME	METERED END
ACP	ASBESTOS CEMENT PIPE	EQUIP	EQUIPMENT	MECH	MECHANICAL
ADDM	ADDENDUM	ECR	ECCENTRIC REDUCER	MEGH	MATCH EXISTING GRADE
ADH	ADHESIVE	ESTM	EASEMENT	MFR	MANUFACTURE(R)
AF	AFRICANA FINISHED FLOOR	EST	ESTIMATE(D)	MG	MILLION GALLONS
AFG	ABOVE FINISHED GRADE	ET	ELECTRIC TRANSFORMER	ML	MILLION GALLONS PER DAY
AFS	ABOVE FINISHED SLAB	EW	EACH WAY	MH	MANHOLE
AHD	AHEAD	EXC	EXCAVATE	MI	MILE(S)
AL	ALUMINUM	EXP	EXPANSION	MIN	MINIMUM, MINUTE(S)
ALT	ALTERNATE	EXST	EXISTING	MISC	MISCELLANEOUS
AMP	AMPERE	EXST GR	EXISTING GRADE	MJ	MECHANICAL JOINT
AMT	AMOUNT	EXT	EXTERIOR	ML	MIXED LIQUOR
ANT	ANTENNA	EXTN	EXTENSION	MO	MASONRY OPENING
APRX	APPROXIMATE(LY)			MON	MONUMENT
ARCH	ARCHITECTURAL	F	FOUND	MPH	MILES PER HOUR
AS	ALUM SOLUTION	FCA	FLANGED COUPLING ADAPTER	MT	MALE PIPE THREAD
ASPH	ASPHALT	FB	FLAT BAR	MS	MOTOR STARTER
ASSY	ASSEMBLY	FCV	FLOW-CONTROL VALVE	MSP	MOTOR STARTER PANEL
AVE	AVENUE	FD	FLOOR DRAIN	MOTD	MOUNTED
AW	AIR CONDITIONING	FE	FOUNDATION	MTR	MOTORING VALVE
AVV	AIR/VACUUM AIR VALVE	FDC	FIRE DEPT CONNECTION	MW	MONITORING WELL
		FE	FILTER(ED) EFFLUENT	MWL	MEAN WATER LEVEL
		FF	FINISH FLOOR		MAXIMUM WORKING PRESSURE
B		FFH	FIRE HYDRANT	N	
BAF	BAFFLE	FIG	FIGURE	N	
BCV	BLK CHECK VALVE	FIN	FINISH(ED)	N	
BF	BLIND FLANGE	FIN GR	FINISH GRADE	ND	NORTH
BFV	BUTTERFLY VALVE	FL	FLUORIDE	NE	NAIL & DISK
BHP	BRAKE HORSEPOWER	FLG	FLANGE(D)	NE	NORTHEAST
BI	BLACK IRON	FL	FLOW LINE	NIC	NOT IN CONTRACT
BL	BASELINE	FLTR	FILTER	NL	NAIL
BLDG	BUILDING	FM	FORCE MAIN	NO	NUMBER
BLK	BLOCK	FO	FIBER OPTIC	NOM	NOMINAL
BM	BENCH MARK	FP	FEET PER MINUTE	NPF	NATIONAL PIPE THREAD
BCC	BACK OF CURB	FPS	FEET PER SECOND	NP	NATIONAL PIPE TAPER
BO	BOTTOM	FRP	FIBERGLASS REINFORCED	NPW	NON-POTABLE WATER
BP	BASE PLATE		PLASTIC	NRS	NON-RISING SYSTEM
BRG	BEARING	FT	FOOT OR FEET	NTS	NOT TO SCALE
BSP	BLACK STEEL PIPE	FUT	FUTURE	NW	NORTHWEST
BV	BALL VALVE	FV	FOOT VALVE	NA	NOT APPLICABLE
BW	BOTH WAYS	FW	FINISHED WATER		
BWW	BACKWASH WATER	FWP	FACTORY WIRED PANEL	O	
		F/F	FACE TO FACE	OC	ON CENTER
C				OD	OUTSIDE DIAMETER
CAP	CAPACITY	G	GAS	ODP	OPEN DRIP PROOF
CAV	COMBINATION AIR VALVE	G	GAS	OE	OVERHEAD UTILITY LINES
CB	CATCH BASIN	GA	GAUGE	OF	OUTSIDE FACE
CCC	CHLORINE CONTACT CHAMBER	GAL	GALLON(S)	OH	OVER HEAD
CC	CHLORINATED CEMENT	GALV	GALVANIZED	OHV	OVER HEAD WIRE
CFM	CUBIC FEET PER MINUTE	GIP	GALVANIZED IRON PIPE	OP	OPPOSITE
CFS	CUBIC FEET PER SECOND	GJ	GROOVE JOINT	OPT	OPTIONAL
CV	CHECK VALVE	GM	GAS METER	OR	OFFICIAL RECORDS
CI	CAST IRON	GND	GROUND	OSY	OUTSIDE SCREW AND YOKE
CIC	CAST IRON PIPE	GPD	GALLONS PER DAY	O&M	OPERATION AND MAINTENANCE
CISP	CAST IRON SOIL PIPE	GPH	GALLONS PER HOUR		
CJ	CONSTRUCTION JOINT	GPM	GALLONS PER MINUTE	P	
CKT	CIRCUIT	GPS	GALLONS PER SECOND	P	POST
CL	CENTER LINE	GR	GRADE	PA	PROCESS AIR
CLF	CHAIN LINK FENCE	GRG	GRATING	PB	PLAT BOOK
CLR	CLEAR OR CLEARANCE	GS	GALVANIZED STEEL	PC	POINT OF CURVE
CLVT	CULVERT	GSP	GALVANIZED STEEL PIPE	PCM	PERMANENT CONTROL
CM	CONCRETE MONUMENT	GSR	GROUND STORAGE RESERVOIR		MONUMENT
CMP	CORRUGATED METAL PIPE	GST	GROUND STORAGE TANK	PE	PLAIN END
CMPA	CORRUGATED METAL PIPE	GT	GROUT	PAGE	
	ARCH	GV	GATE VALVE	PI	POINT OF INTERSECTION
CMU	CONCRETE MASONRY UNIT			PK	PK NAIL
CND	CONDUIT	H	HOSE	PL	PLATE
CNR	CORNER	H	HOSE BIBB	PIL	PROPERTY LINE
CO	CLEAN OUT	HD	HEAVY-DUTY	PIN	PINCH VALVE
COAG	COAGULANT	HDD	HORIZONTAL DIRECTIONAL DRILL	POB	POINT OF BEGINNING
COL	COLUMN	HDPE	HIGH-DENSITY POLYETHYLENE	POJ	PUSH-ON JOINT
COM	COMMON	HDR	HYDRAULIC	POL	POLYMER
CONC	CONCRETE	HFA	HYDROLYSIS/SLICIC ACID	PP	POWER POLE
CONN	CONNECTION	HGT	HEIGHT	PPD	POUNDS PER DAY
CONSTR	CONSTRUCTION(ION)	HNDRL	HAND RAIL	PPM	PARTS PER MILLION
CONT	CONTINUOUS	HOA	HAND-OFF-AUTO	PREFAB	PREFABRICATED
CONTR	CONTRACTOR(OR)	HORIZ	HORIZONTAL	PRS	PRESSURE
COORD	COORD				

LEGEND		LEGEND		LEGEND	
	AIR RELEASE VALVE		FIRE VALVE		SANITARY SEWER LINE
	AUTO VACUUM		FLAG POLE		SEWER MANHOLE
	BACKFLOW PREVENTER		FORCE MAIN		SEWER VALVE
	BENCH MARK		FORCE MAIN AIR RELEASE VALVE		SECURITY SENSOR
	BOLLARD		GAS PIPELINE MARKER		SIGN SINGLE POST
	CABLE RISER		GAS VALVE		SIGN DOUBLE POST
	CABLE TV BOX		GATE KEY PAD		SPRINKLER
	CATCH BASIN		GROUND LIGHT		STEEL POST
	CENTERLINE		GREASE MANHOLE		TELEPHONE BOX OR VAULT
	CLEANOUT		GUARD RAIL		TELEPHONE CANISTER
	COORDINATE NUMBER		GUY POLE		TELEPHONE FLAG
	CONCRETE POWER POLE		GUY WIRE		TELEPHONE MANHOLE
	CONCRETE POST		HANDI-CAP PARKING		TELEPHONE RISER
	DRAINAGE MANHOLE		HOSE BIB		TOE OF SLOPE
	ELECTRICAL BOX		IRRIGATION BOX		TOP OF BANK
	ELECTRIC OUTLET		IRRIGATION VALVE		TRAFFIC SIGNAL BOX
	ELECTRIC METER		LIGHT POLE		TRAFFIC SIGNAL POLE
	ELECTRIC TRANSFORMER W/ PAD		MAIL BOX		TRAFFIC SIGNAL LIGHT
	ELECTRIC LINE		MITERED END		UNDERGROUND UTILITIES
	ELECTRIC FLAG		WELL		UNKNOWN UTILITY VAULT
	EXISTING ELEVATION		OVERHEAD POWER LINE		WATER MAIN
	FENCE - BARBED WIRE		OVERHEAD TELEPHONE LINE		WATER LINE FLAG
	FENCE - CHAIN LINK / U.O.N.		PARKING PAY METER		WATER METER
	FENCE - WOOD / U.O.N.		POWER POLE		WATER VALVE
	FIBER OPTIC MARKER / POST		POWER POLE w/ RISER		WOOD POST
	FIBER OPTIC BOX		RECLAIM WATER LINE FLAG		WOOD SUPPORT POLE
	FIRE HYDRANT		SEWER LINE FLAG		YARD DRAIN
					CROSS WALK SIGNAL POLE
					CROSS WALK BUTTON POLE
					BUSH
					CABBAGE PALM
					OAK TREE
					PALM TREE
					PINE TREE
					SHADE TREE (VARIOUS TYPE)
					FOUND CONCRETE MONUMENT
					FOUND DRILL HOLE
					FOUND IRON ROD
					FOUND IRON ROD & CAP
					FOUND NAIL
					FOUND NAIL & DISK
					FOUND PARKER KALON NAIL
					FOUND PARKER KALON NAIL & DISK
					SET CONCRETE MONUMENT
					SET DRILL HOLE
					SET 5/8" IRON ROD & CAP "CARDNO LB 7975" U.O.N.
					SET MAG NAIL & DISK "CARDNO LB 7975" U.O.N.
					CONCRETE
					HEAVY VEGETATION LANDSCAPING

	PROPERTY LINE
	RIGHT OF WAY LINE (R-O-W)
	EASEMENT
	PROPOSED CONTOUR MAJOR
	PROPOSED CONTOUR MINOR (LABEL OPTIONAL)
	WATER MAIN
	WATER MAIN (DIRECTIONAL DRILL)
	STORM WATER
	SANITARY SEWER
	SANITARY SEWER (FORCE MAIN)
	STEEL FENCE
	WOOD FENCE
	SILT FENCE
	TURBIDITY BARRIER
	VEGETATION
	+ ^{BM} BENCHMARK
	△ ND NAIL & DISK
	△ ^{TP} TRAVERSE POINT
	● ^F FOUND IRON (TYPE)
	○ ^S SET IRON (TYPE)
	■ ^F FOUND MONUMENT (TYPE)
	□ ^S SET MONUMENT (TYPE)
	⊕ ^{SC} SECTION CORNER
	○ ^{CO} CLEANOUT
	○ DECIDUOUS TREE
	+ SPIGOT
	* SPRINKLER HEAD
	△ TRAFFIC SIGN
	□ UTILITY MARKER (AS SHOWN)
	⊗ WELL
	XXXX SPOT ELEVATION
	⊞ ELECTRIC TRANSFORMER
	★ EVERGREEN TREE
	☆ FIRE HYDRANT
	★ FLAG (AS SHOWN)
	★ GUY ANCHOR
	★ LIGHT POLE
	⊞ MAIL BOX
	★ PALM TREE
	○ ^P POST
	⊞ SATELLITE DISH
	⊞ UTILITY MANHOLE (AS SHOWN)
	⊞ UTILITY METER (AS SHOWN)
	⊞ UTILITY RISER (AS SHOWN)
	⊞ UTILITY VALVE (AS SHOWN)
	⊞ UTILITY POLE (AS SHOWN)
	⊞ POWER POLE

DENOTES SECTION LETTER IDENTIFICATION DENOTES DRAWING NO WHERE SECTION IS LOCATED <u>SECTION REFERENCE</u>	DENOTES DETAIL NUMBER IDENTIFICATION DENOTES DRAWING NO WHERE DETAIL IS LOCATED <u>DETAIL REFERENCE</u>
DENOTES SECTION LETTER IDENTIFICATION SECTION SCALE: DENOTES DRAWING NO WHERE SECTION IS LOCATED <u>SECTION TITLE</u>	DENOTES DETAIL NUMBER IDENTIFICATION DETAIL SCALE: DENOTES DRAWING NO WHERE DETAIL IS LOCATED <u>DETAIL TITLE</u>

	ASPHALT OR CONCRETE SURFACE (SIDEWALK OR ROADWAY)		GRAVEL
	OPEN CUT EXISTING PAVEMENT		GROUT
	REMOVE AND REPLACE DRIVEWAY/SIDEWALK		ARMORFLEX
	SODDED OR SEEDDED AND MULCHED AREA OR EXISTING WETLAND		STEEL
	EARTH		ALUMINUM
	CAST-IN-PLACE CONCRETE		GRATING

	<u>EXISTING</u>	<u>PROPOSED</u>
VISIBLE LINE		
HIDDEN LINE		
CENTER LINE		
PHANTOM LINE		
MATCHLINE		

1 3/32"

NOTE

G-002

2004, 2005, 2006, 2685, 26

PHONE: (239) 390-1467 FAX: (407) 839-3790



—

1155

AS

Bar Measures 1 inch

7/15/2020 6:53:45 PM - O:\PROJECTS\ORLANDO\1058\200-01558-19001\CAD\DWG\FILES\C-101 BRANTLEY ROAD PLAN AND PROFILE.DWG - CYR, STEVE

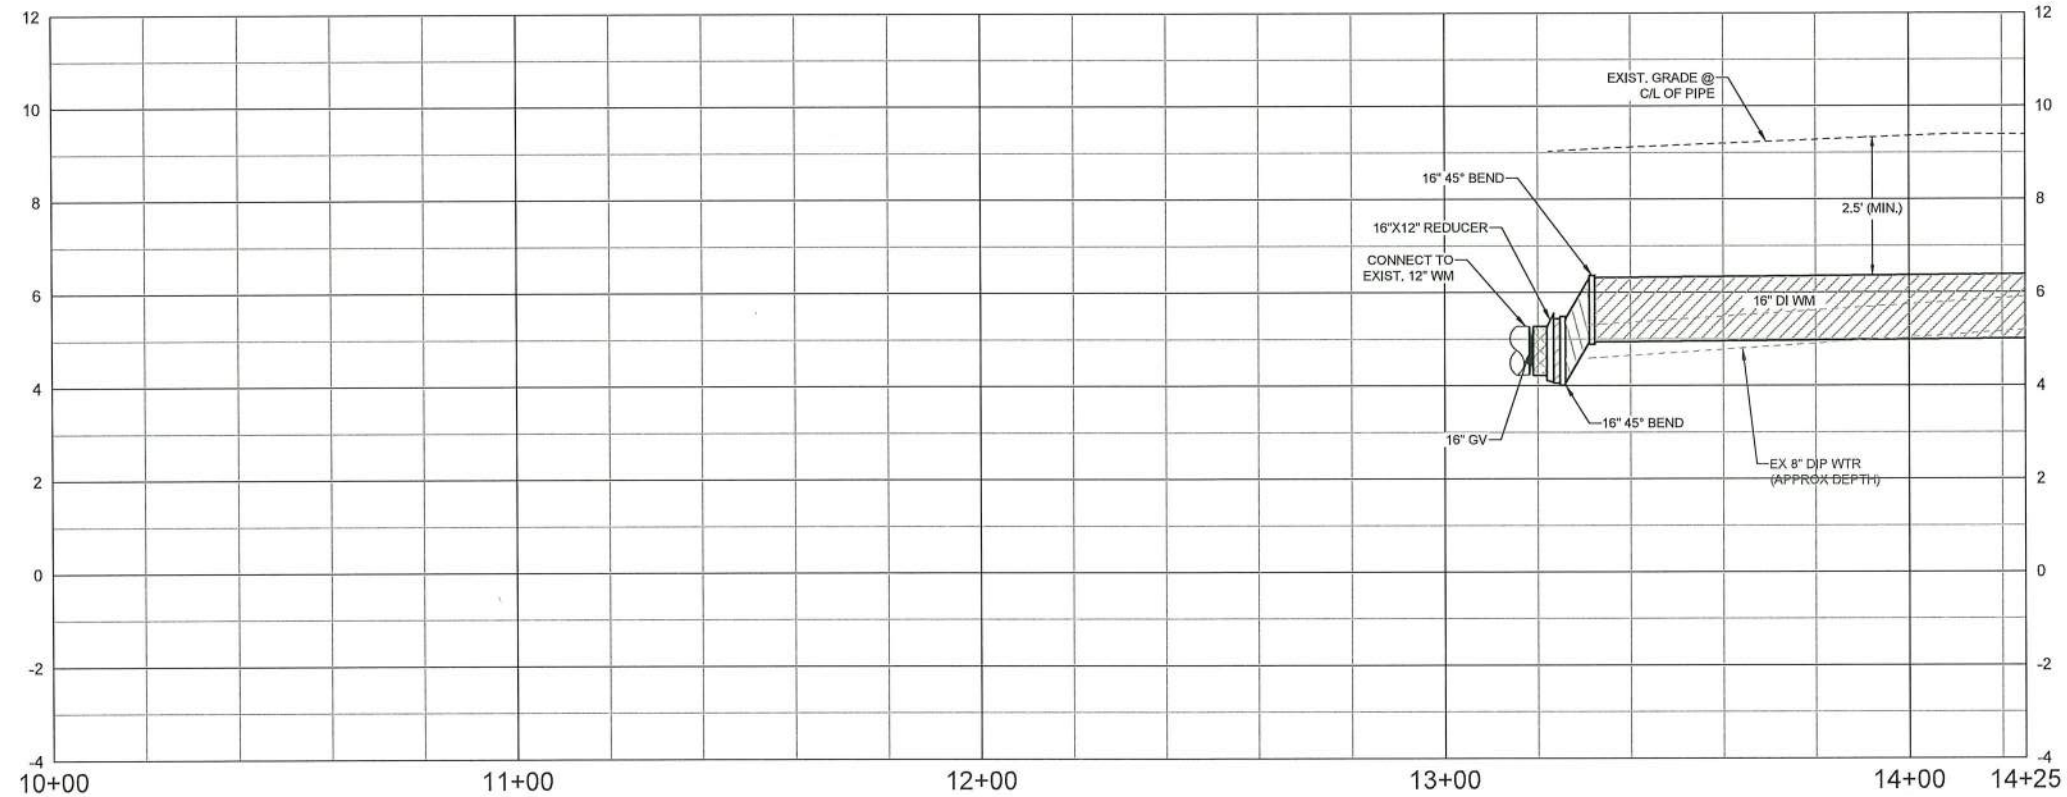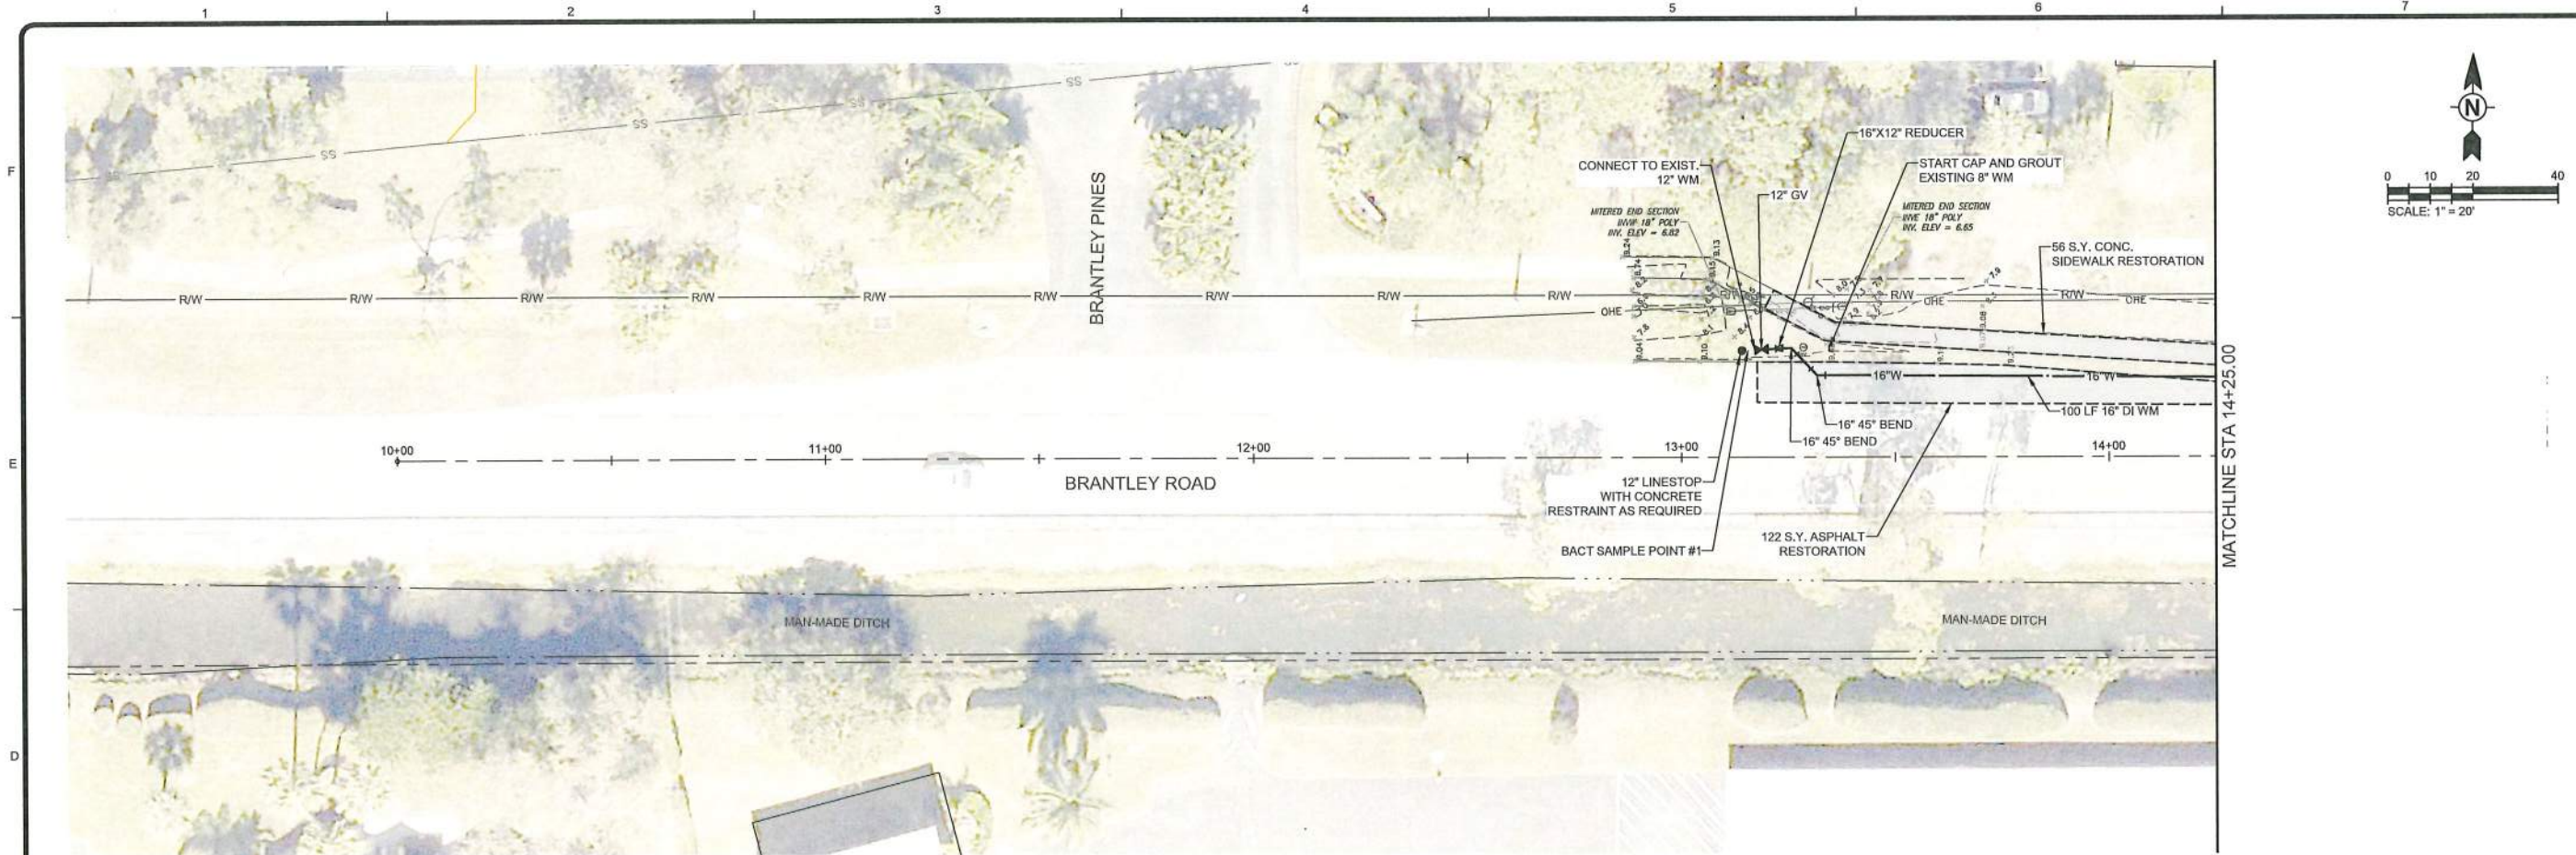

LEE COUNTY UTILITIES
CRYSTAL DRIVE
WATER MAIN IMPROVEMENTS
BRANTLEY ROAD
PLAN AND PROFILE

Project No.: 200-01558-19001
Designed By: AS
Drawn By: WV
Checked By: AS

C-101

TETRA TECH



STEVEN AGAPI, P.E.
LICENSE #68612
Tetra Tech Inc.
10600 Chevrolet Way, Ste. 102
Estero, Florida 33928
Engineering Business No. 2429

www.tetratech.com
10600 CHEVROLET WAY, SUITE 102
ESTERO, FL 33928
PHONE: (239) 390-1487 FAX: (407) 839-3790

Copyright Tetra Tech

Bar Measures 1 inch

7/15/2020 7:05:57 PM - C:\PROJECTS\ORLANDO\VER01558\200-01558-19001\CAD\105\BRANTLEY RD PLAN AND PROFILE.DWG - CYR, STEVE

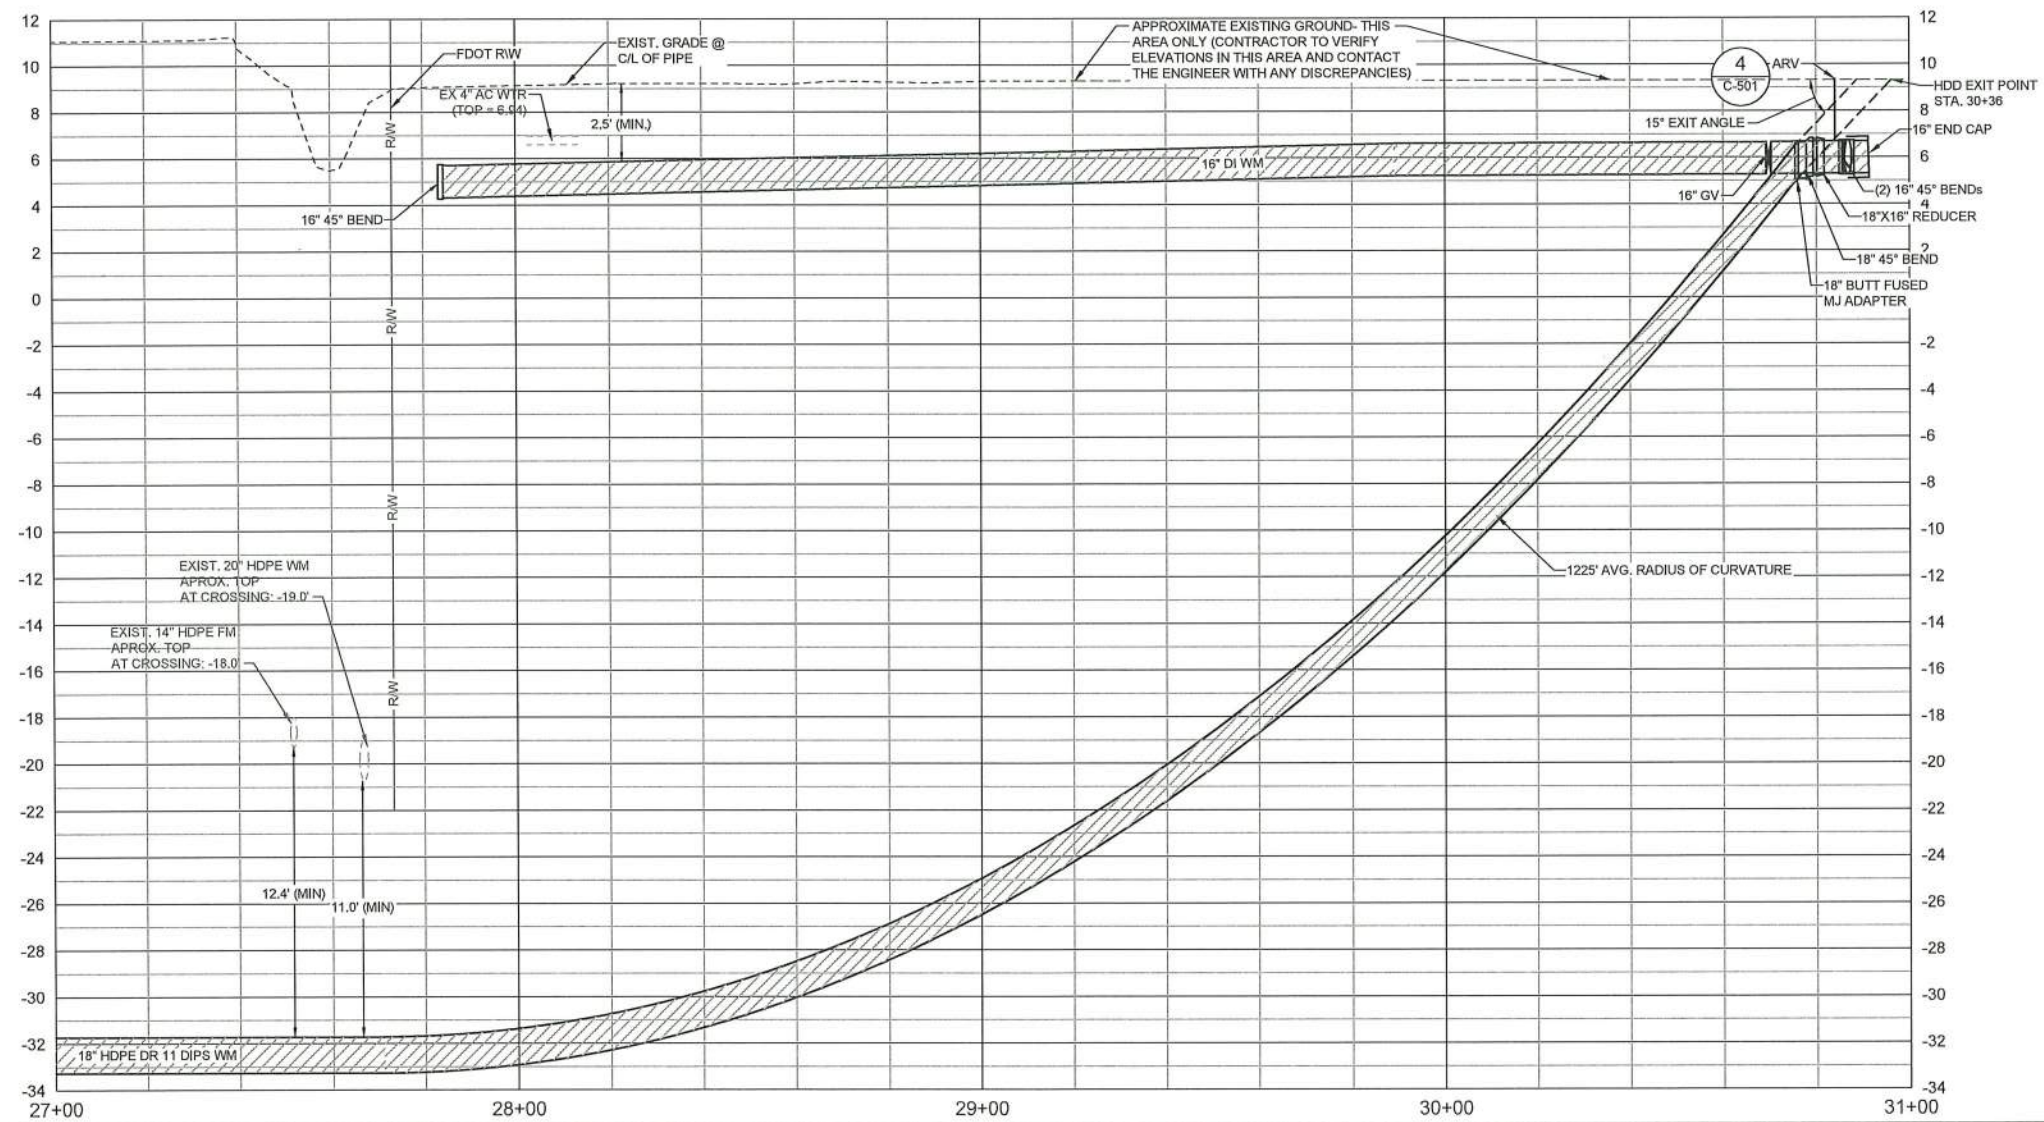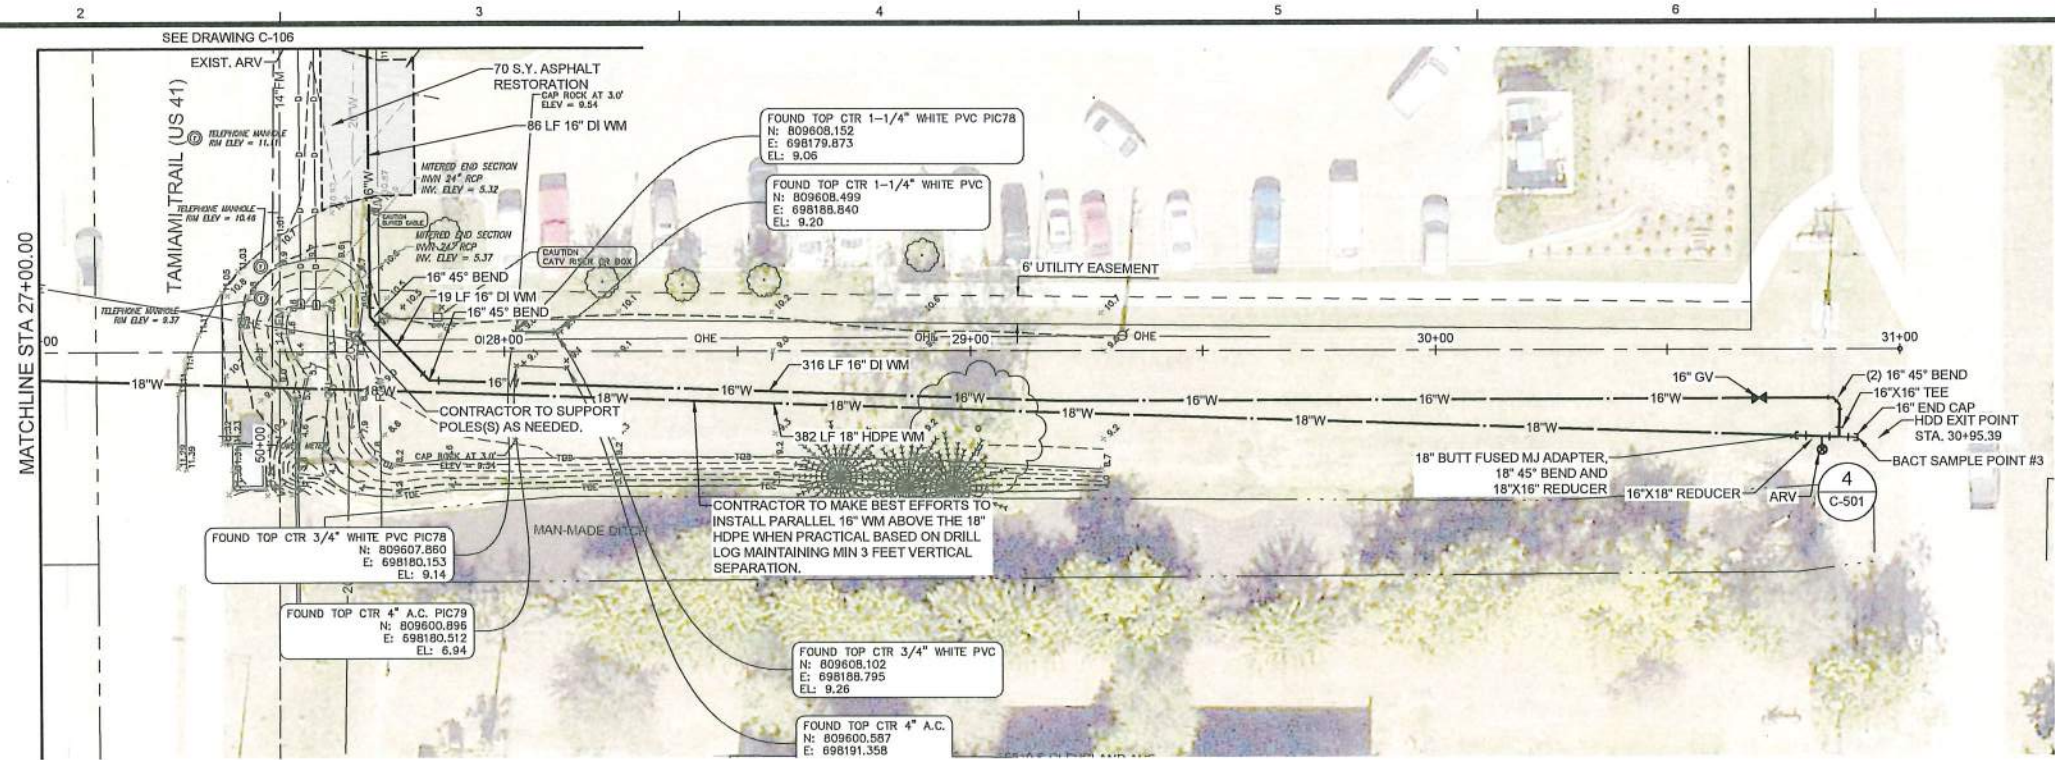

TETRA TECH



STEVEN AGAR, P.E.
LICENSE #68612
Tetra Tech Inc.
10600 Chevrolet Way, Ste. 102
Estero, Florida 33928
Engineering Business No. 2429

DATE



MARK	DATE	DESCRIPTION	BY

LEE COUNTY UTILITIES
CRYSTAL DRIVE
WATER MAIN IMPROVEMENTS
BRANTLEY ROAD
PLAN AND PROFILE

Project No.: 200-01558-19001
Designed By: AS
Drawn By: WV
Checked By: AS

C-105

Bar Measures 1 inch

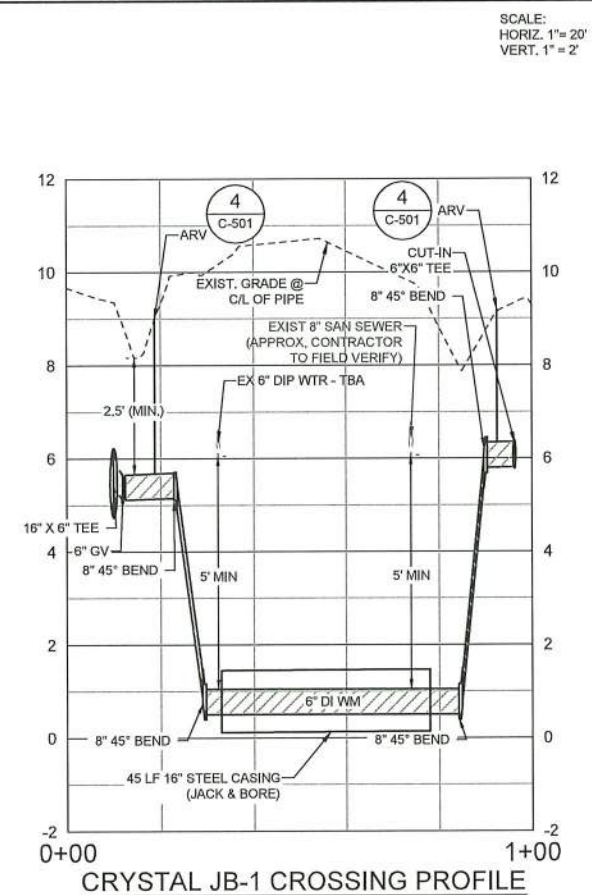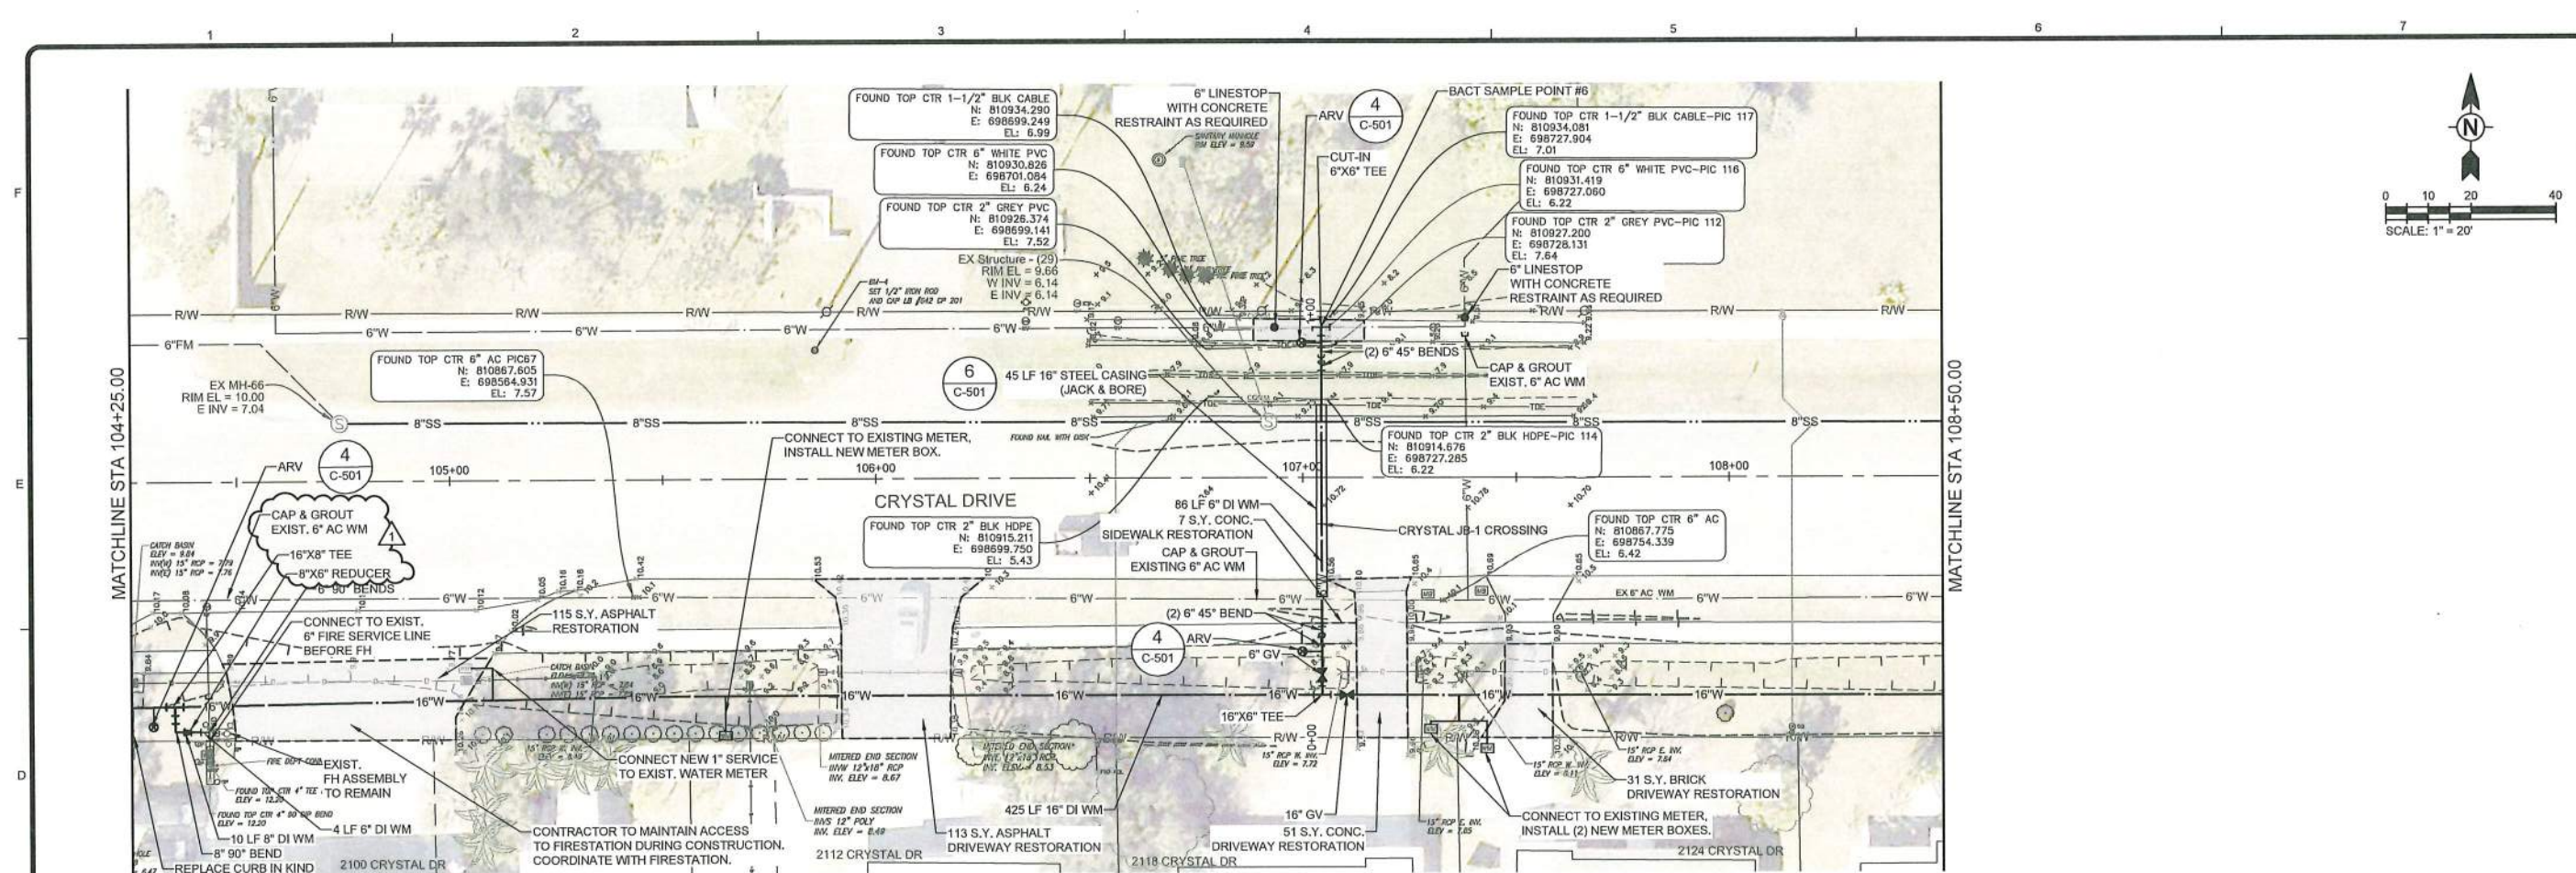

LEE COUNTY UTILITIES
CRYSTAL DRIVE
WATER MAIN IMPROVEMENTS
CRYSTAL DRIVE
PLAN AND PROFILE

Project No.:	200-01558-19001
Designed By:	AS
Drawn By:	WV
Checked By:	AS



C-108

Bar Measures 1 inch

TETRA TECH




STEVEN AGAPI, P.E.
LICENSE #88612
Tetra Tech Inc.
0600 Chevrolet Way, Ste. 102
Estero, Florida 33928
Engineering Business No. 2429

10600 CHEVROLET WAY, SUITE 102
ESTERO, FL 33928
PHONE: (239) 390-1457 FAX: (407) 839-3790

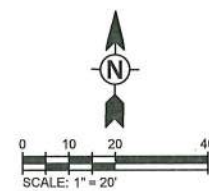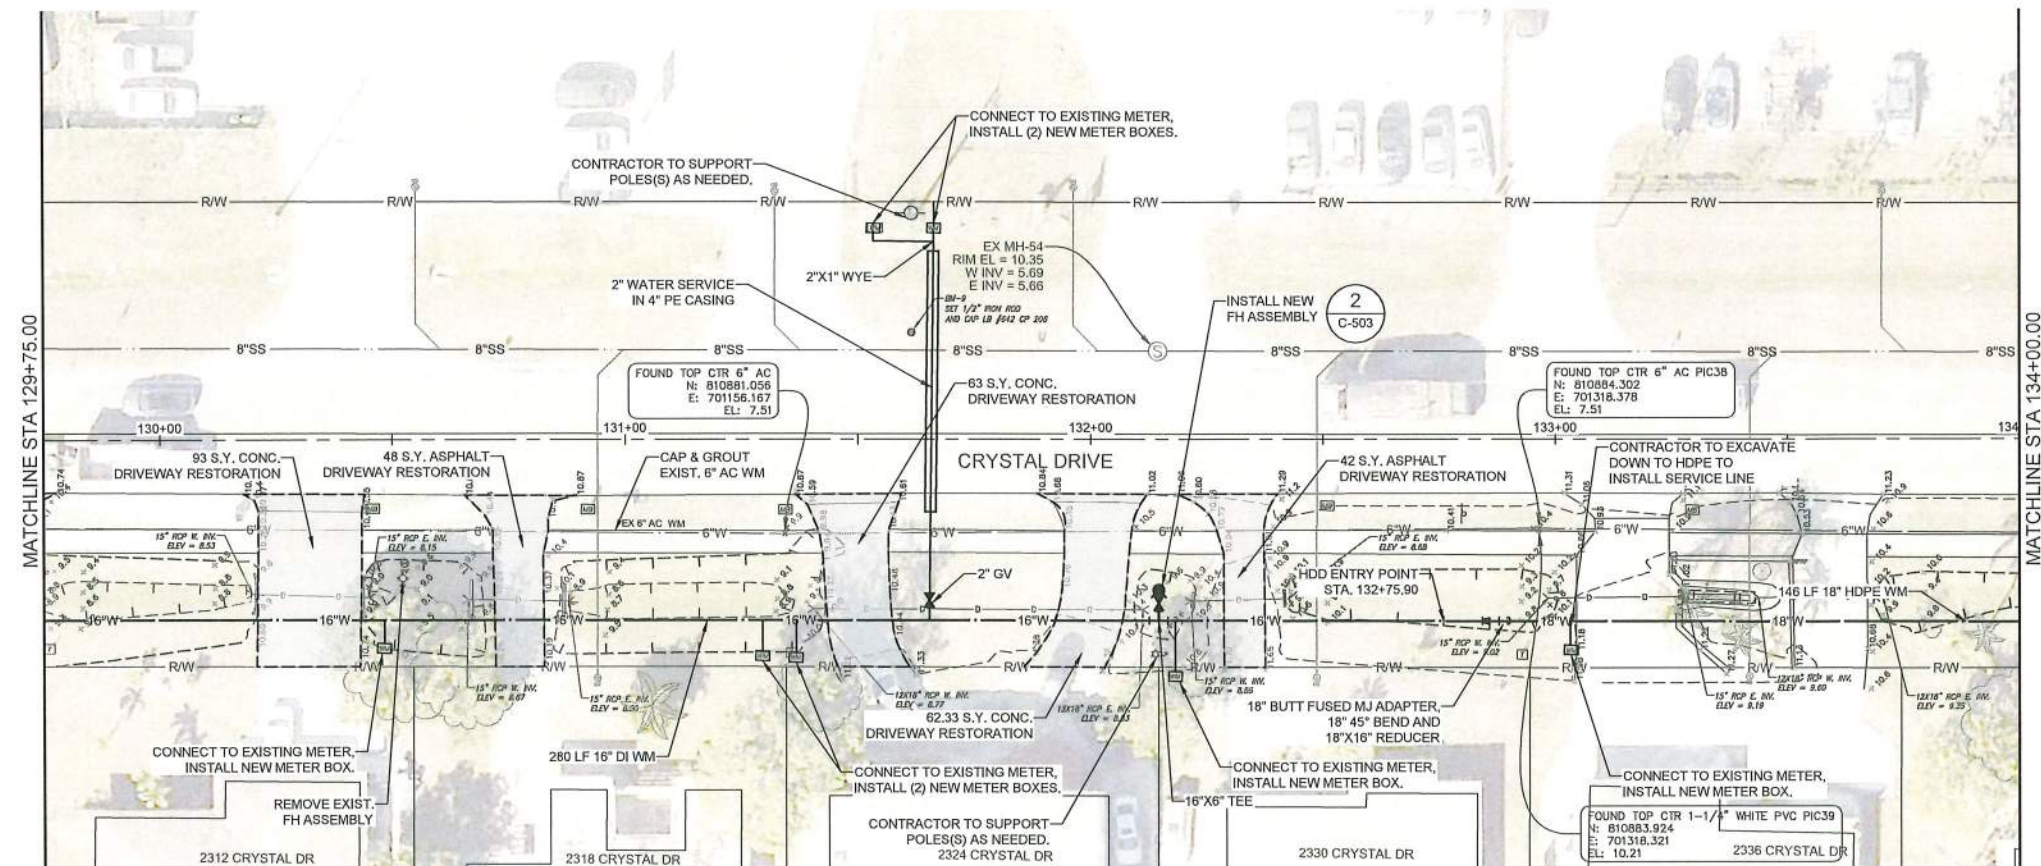[illegible]

Project No.:	200-01558-19001
Designed By:	AS
Drawn By:	WV
Checked By:	AS

7/15/2020 8:50:20 PM - C:\PROJECTS\ORLANDO\1558\200-01558-19001\CAD\DWG\SC-117 CRYSTAL DRIVE PLAN AND PROFILE.DWG - CYR, STEVE

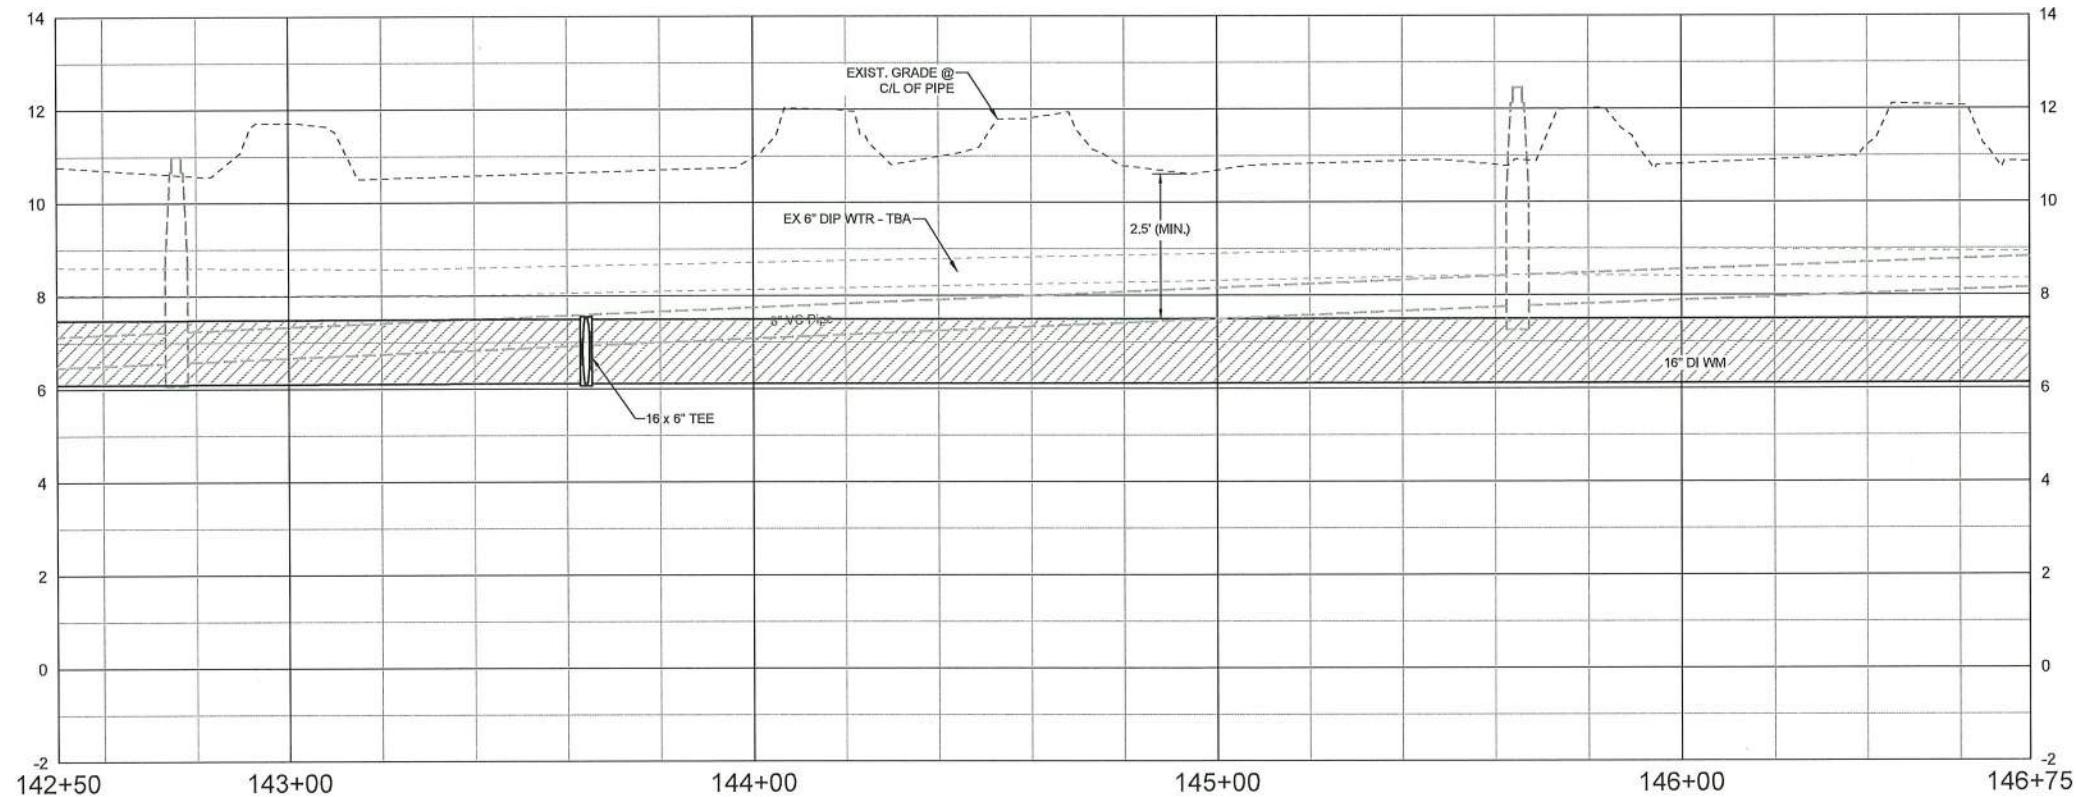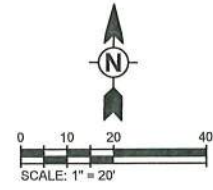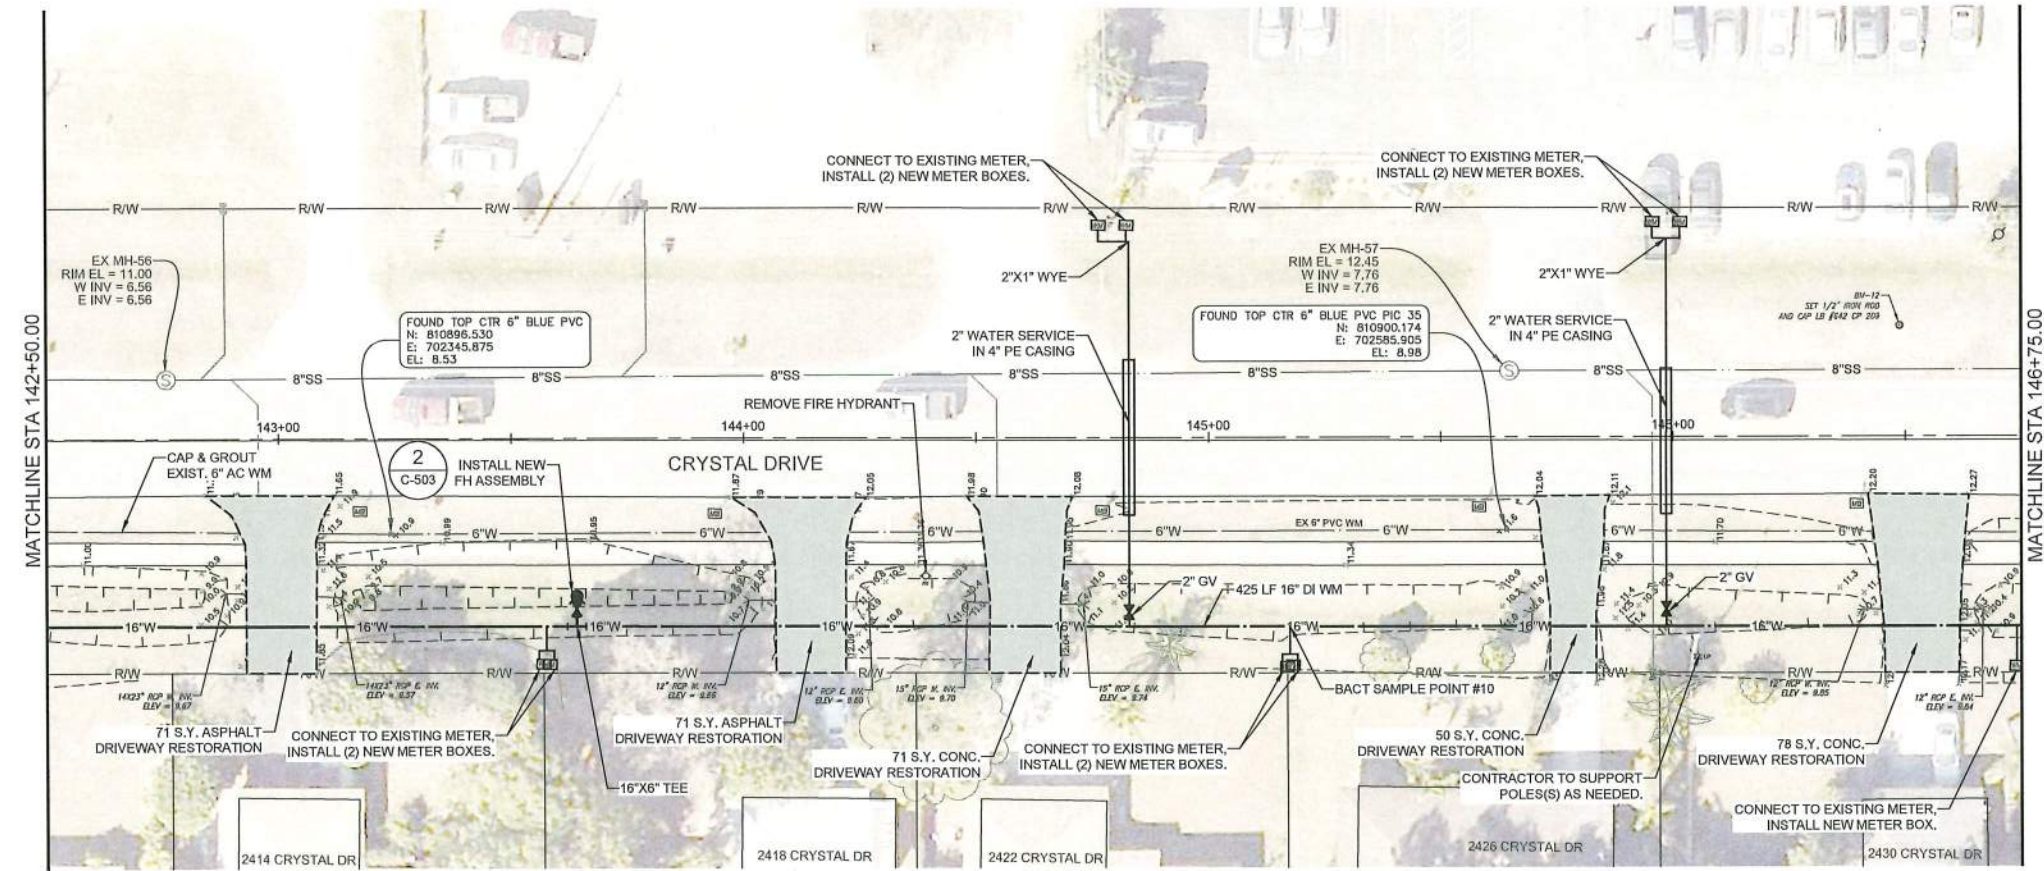

SCALE:
HORIZ. 1"= 20'
VERT. 1"= 2'

**TETRA TECH**

STEVEN AGAPI, P.E.
LICENSE #98612
Tetra Tech Inc.
10600 Chevrolet Way, Ste. 102
Estero, Florida 33928
Engineering Business No. 2429

DATE _____

MARK	DATE	DESCRIPTION

LEE COUNTY UTILITIES
CRYSTAL DRIVE
WATER MAIN IMPROVEMENTS
CRYSTAL DRIVE
PLAN AND PROFILE




Project No.: 200-01558-19001
Designed By: AS
Drawn By: WV
Checked By: AS

C-117

Copyright: Tetra Tech

10600 CHEVROLET WAY, SUITE 102
ESTERO, FL 33928
PHONE: (239) 390-1467 FAX: (407) 839-3790

7/15/2020 7:53:39 PM - C:\PROJECTS\ORLANDO\1558\200-01558-19001\CAD\9SHEETFILES\C-119 CRYSTAL DRIVE PLAN AND PROFILE.DWG - CYR, STEVE

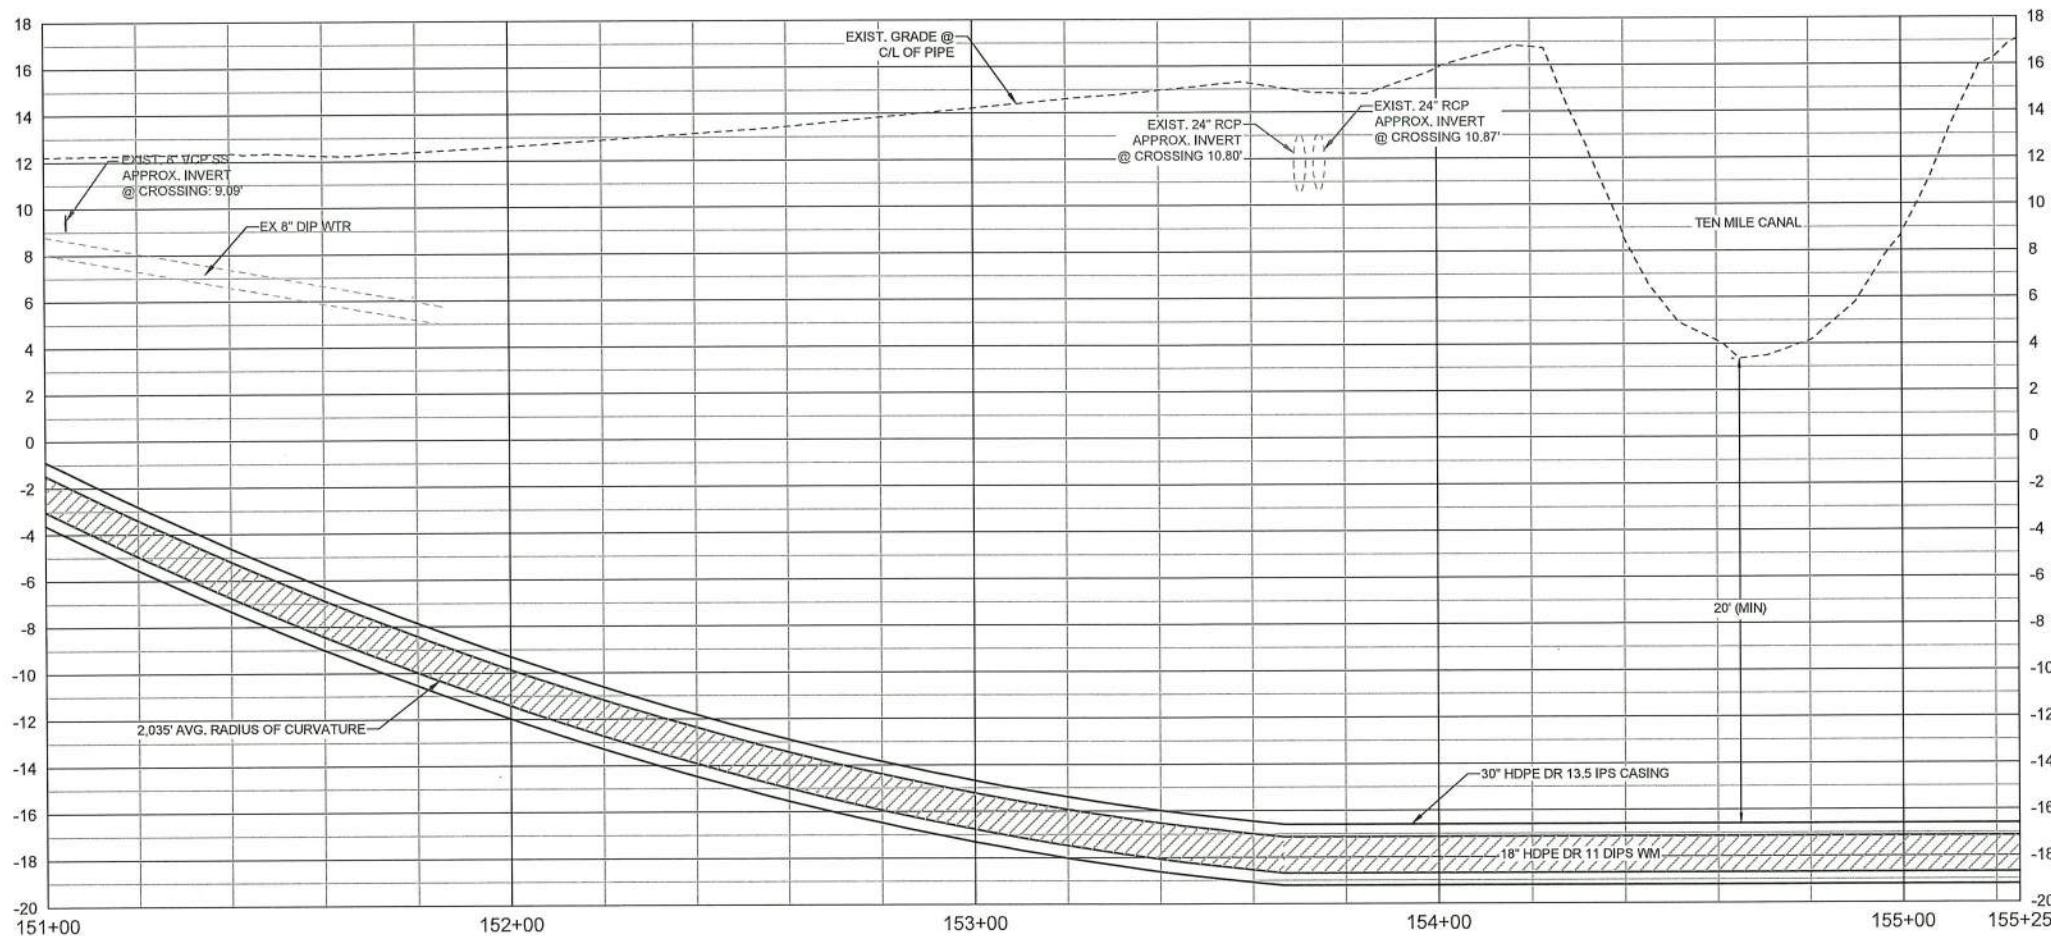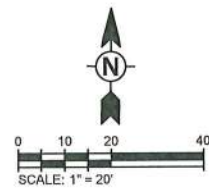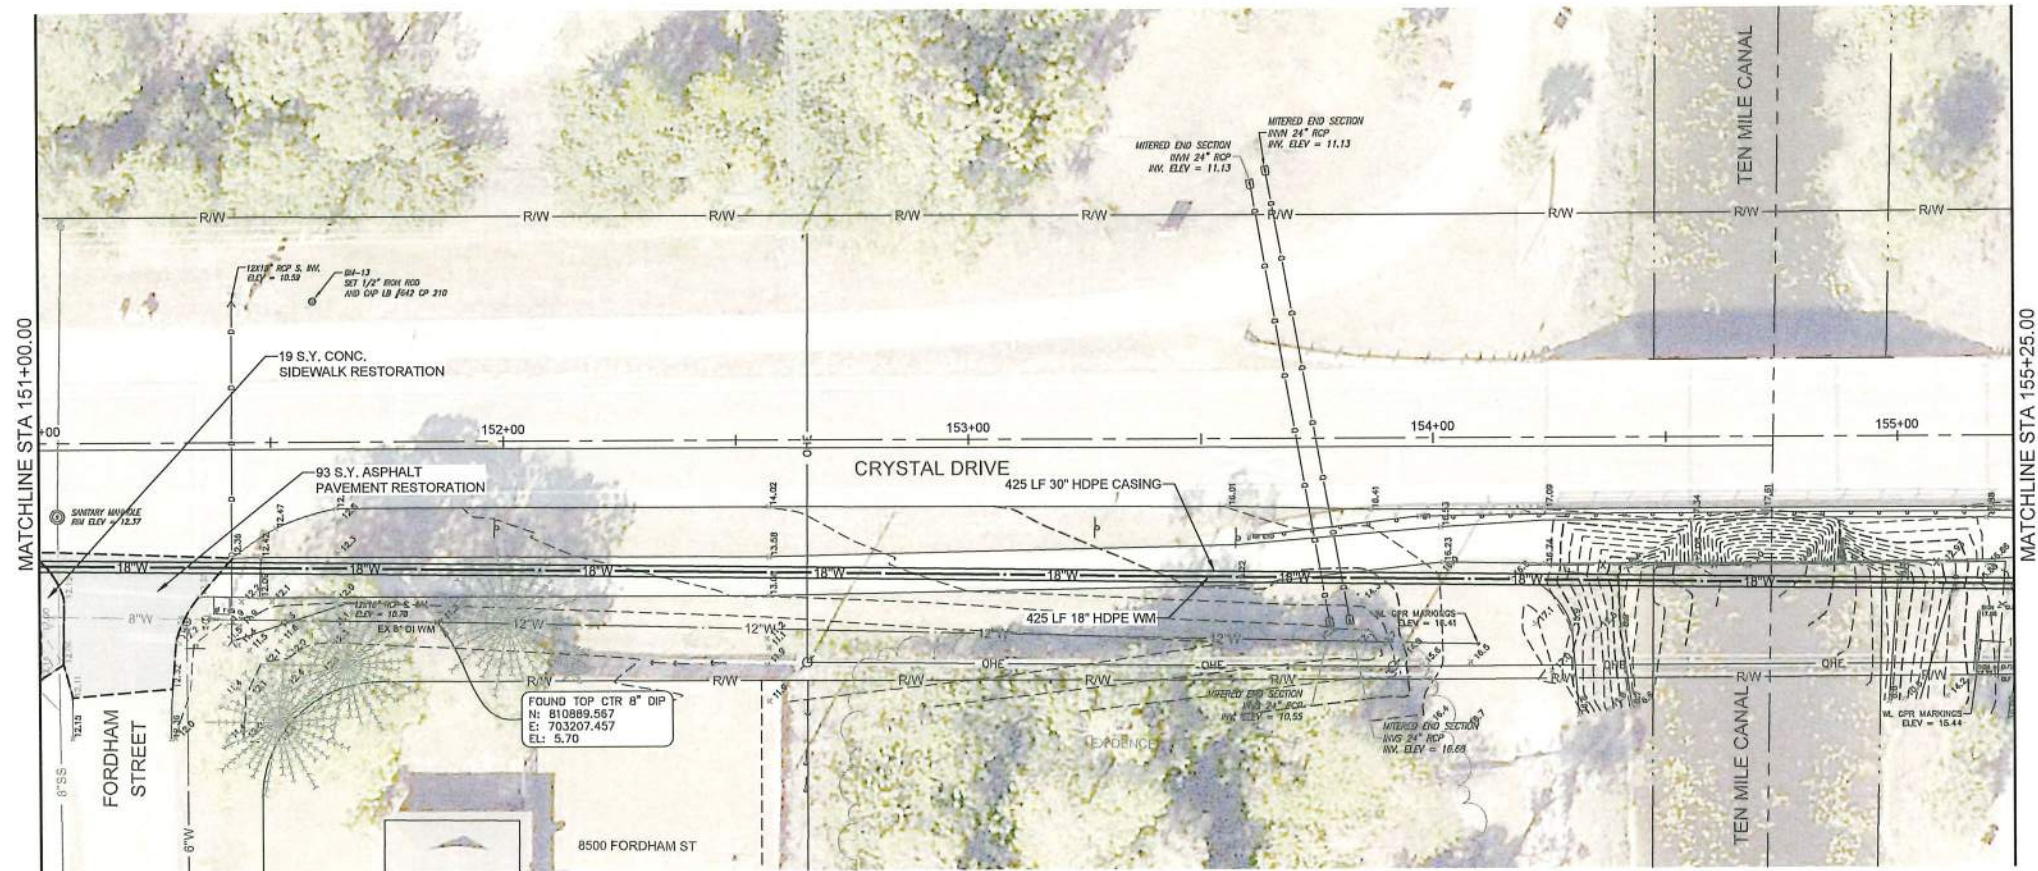

SCALE:
HORIZ. 1"= 20'
VERT. 1"= 4'

LEE COUNTY UTILITIES
CRYSTAL DRIVE
WATER MAIN IMPROVEMENTS
CRYSTAL DRIVE
PLAN AND PROFILE

Project No.: 200-01558-19001
Designed By: AS
Drawn By: WV
Checked By: AS

C-119



STEVEN AGAPI, P.E.
LICENSE #68612
Tetra Tech Inc.
10600 Chevrolet Way, Ste. 102
Estero, Florida 33928
Engineering Business No. 2429


10600 CHEVROLET WAY, SUITE 102
ESTERO, FL 33928
PHONE: (239) 390-1467 FAX: (407) 839-3790
www.tetratech.com

DATE



Bar Measures 1 Inch

Copyright: Tetra Tech

7/15/2020 7:56:41 PM - O:\PROJECTS\ORLANDO\1558\200-01558-19001\CAD\DWG\FILES\C-120 CRYSTAL DRIVE PLAN AND PROFILE.DWG - CYR, STEVE

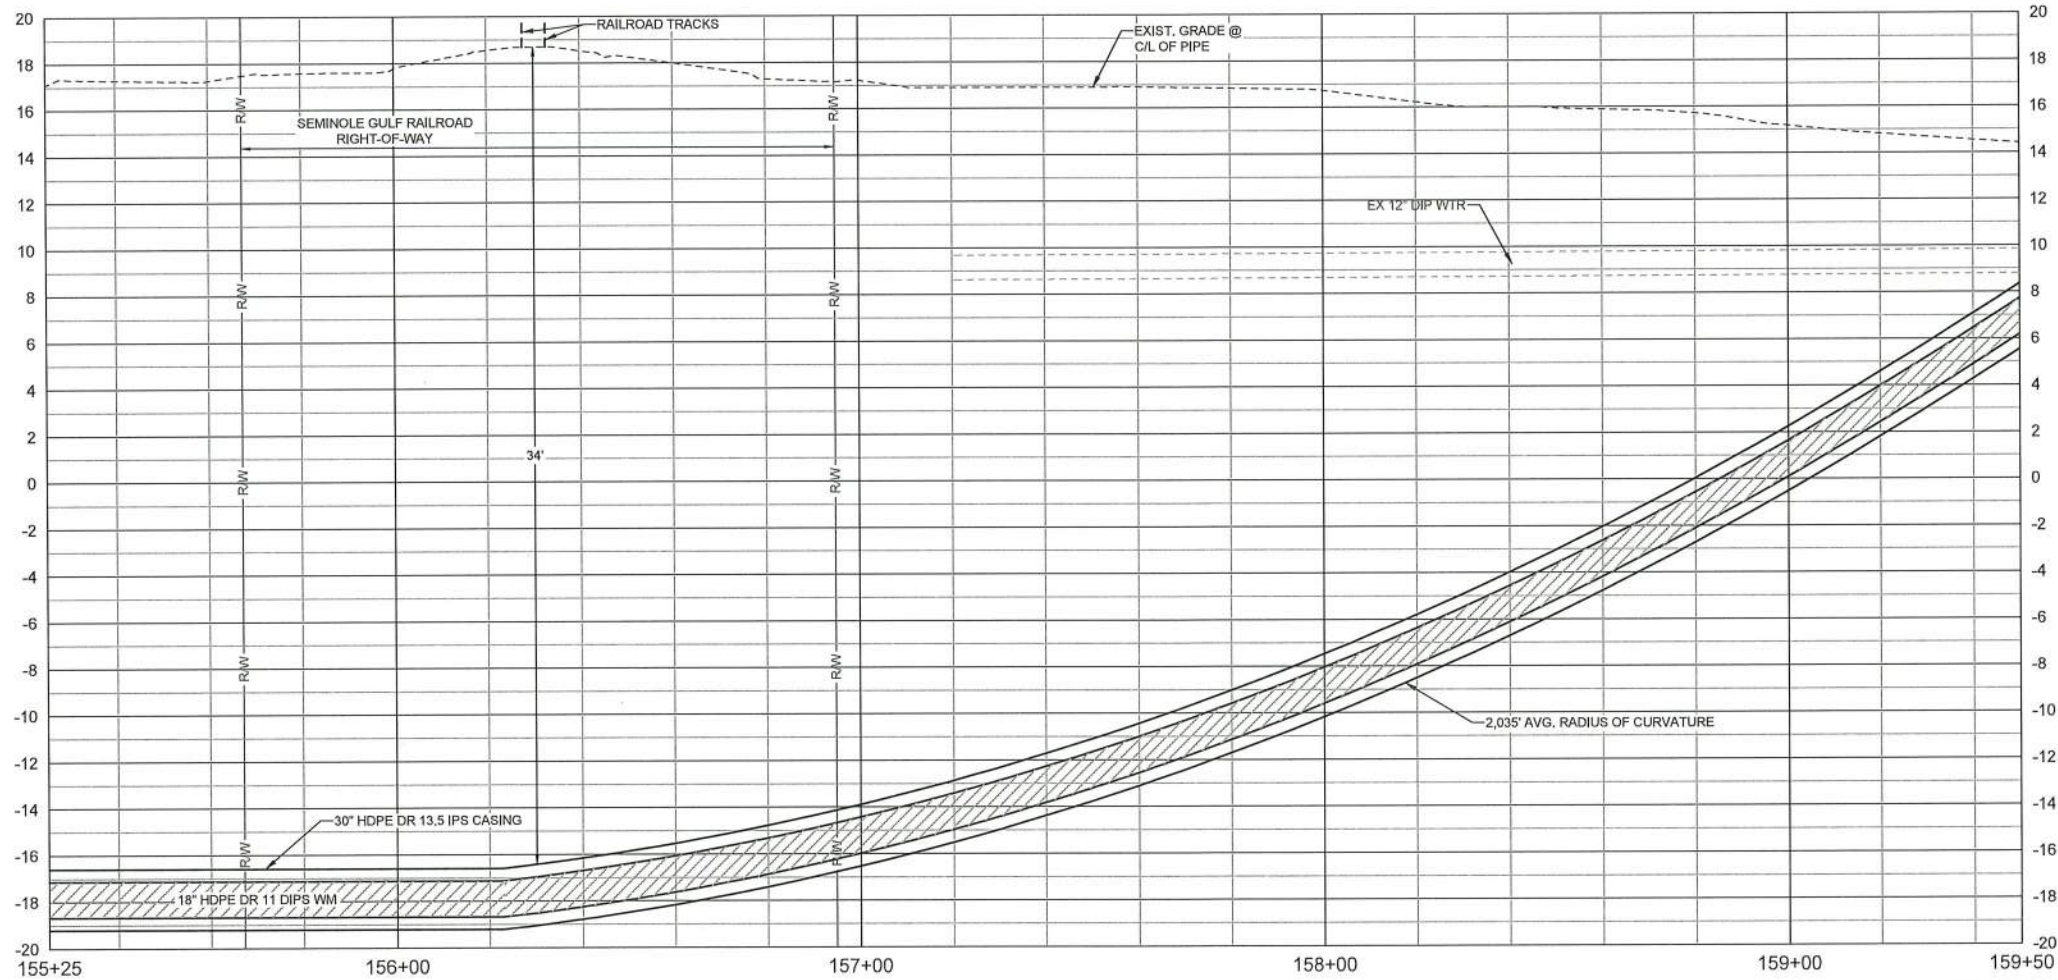

SCALE:
HORIZ. 1" = 20'
VERT. 1" = 4'

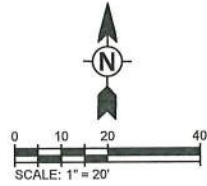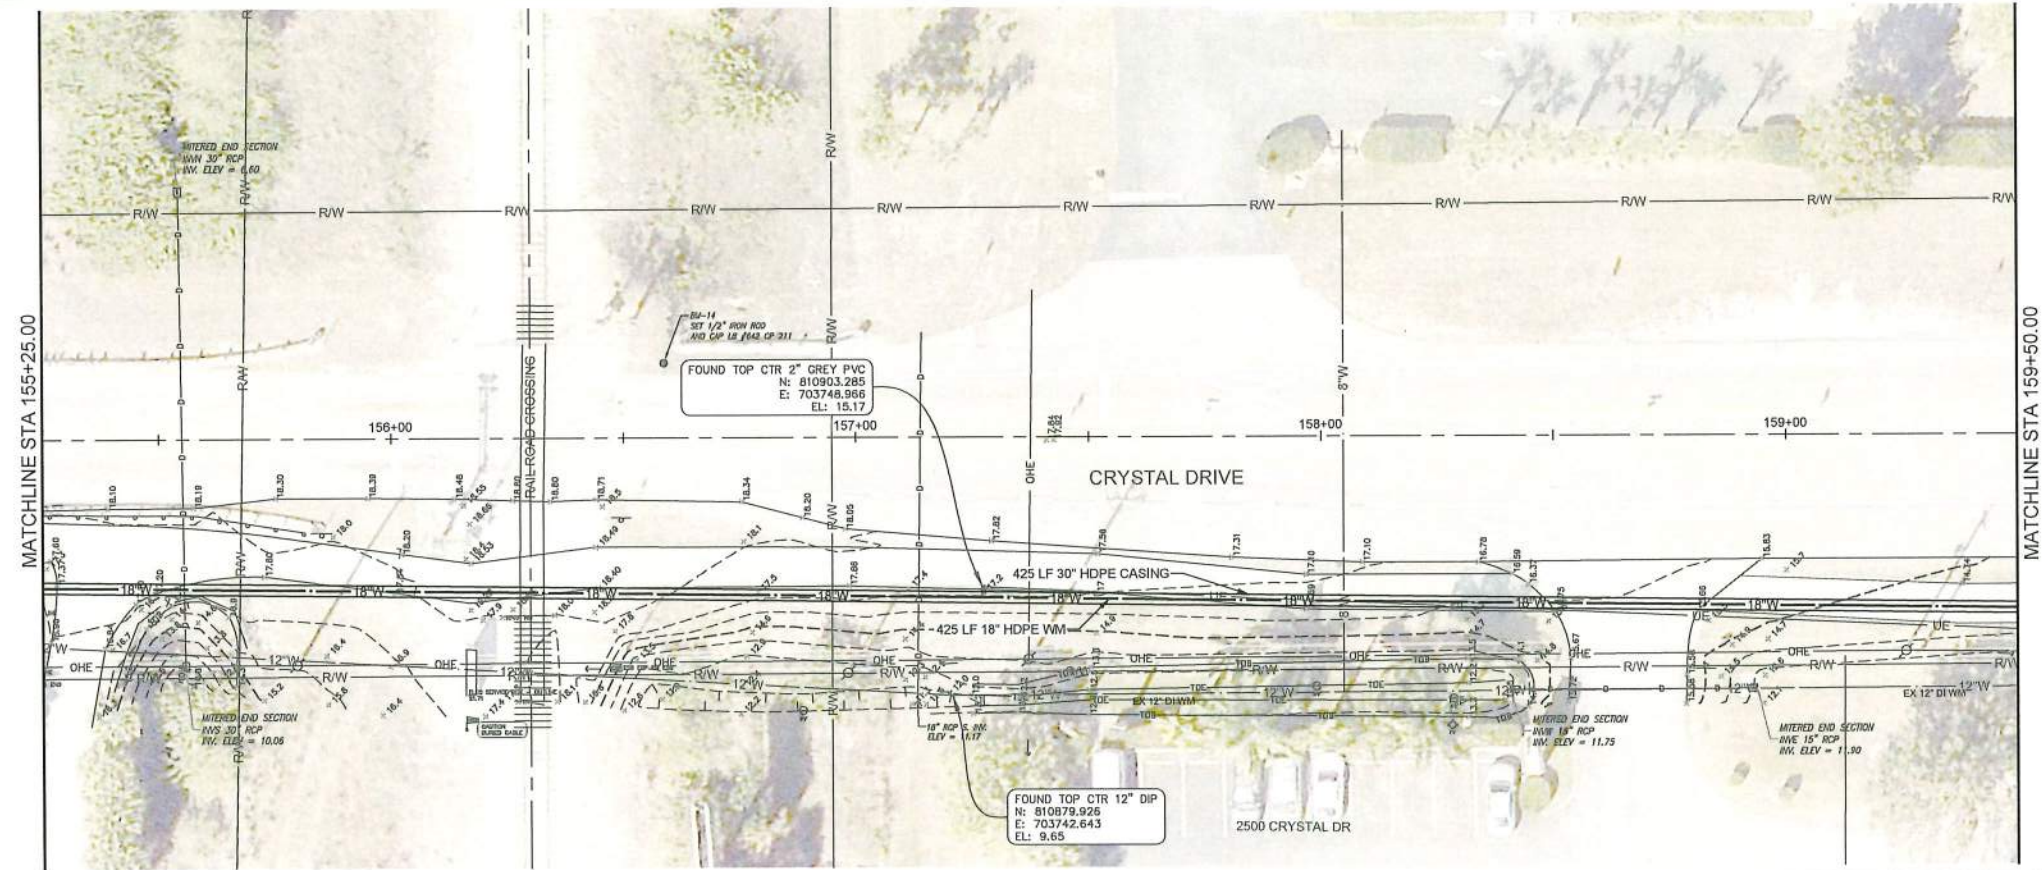

LEE COUNTY UTILITIES
CRYSTAL DRIVE
WATER MAIN IMPROVEMENTS
CRYSTAL DRIVE
PLAN AND PROFILE

Project No.: 200-01558-19001
Designed By: AS
Drawn By: WV
Checked By: AS

C-120

Copyright: Tetra Tech
Bar Measures 1 inch


STEVEN AGAPI, P.E.
LICENSE #66612
Tetra Tech Inc.
10600 Chevrolet Way, Ste. 102
Estero, Florida 33928
Engineering Business No. 2429

DATE




TETRA TECH

www.tetratech.com
10600 CHEVROLET WAY, SUITE 102
ESTERO, FL 33928
PHONE: (239) 390-1487 FAX: (407) 839-3790

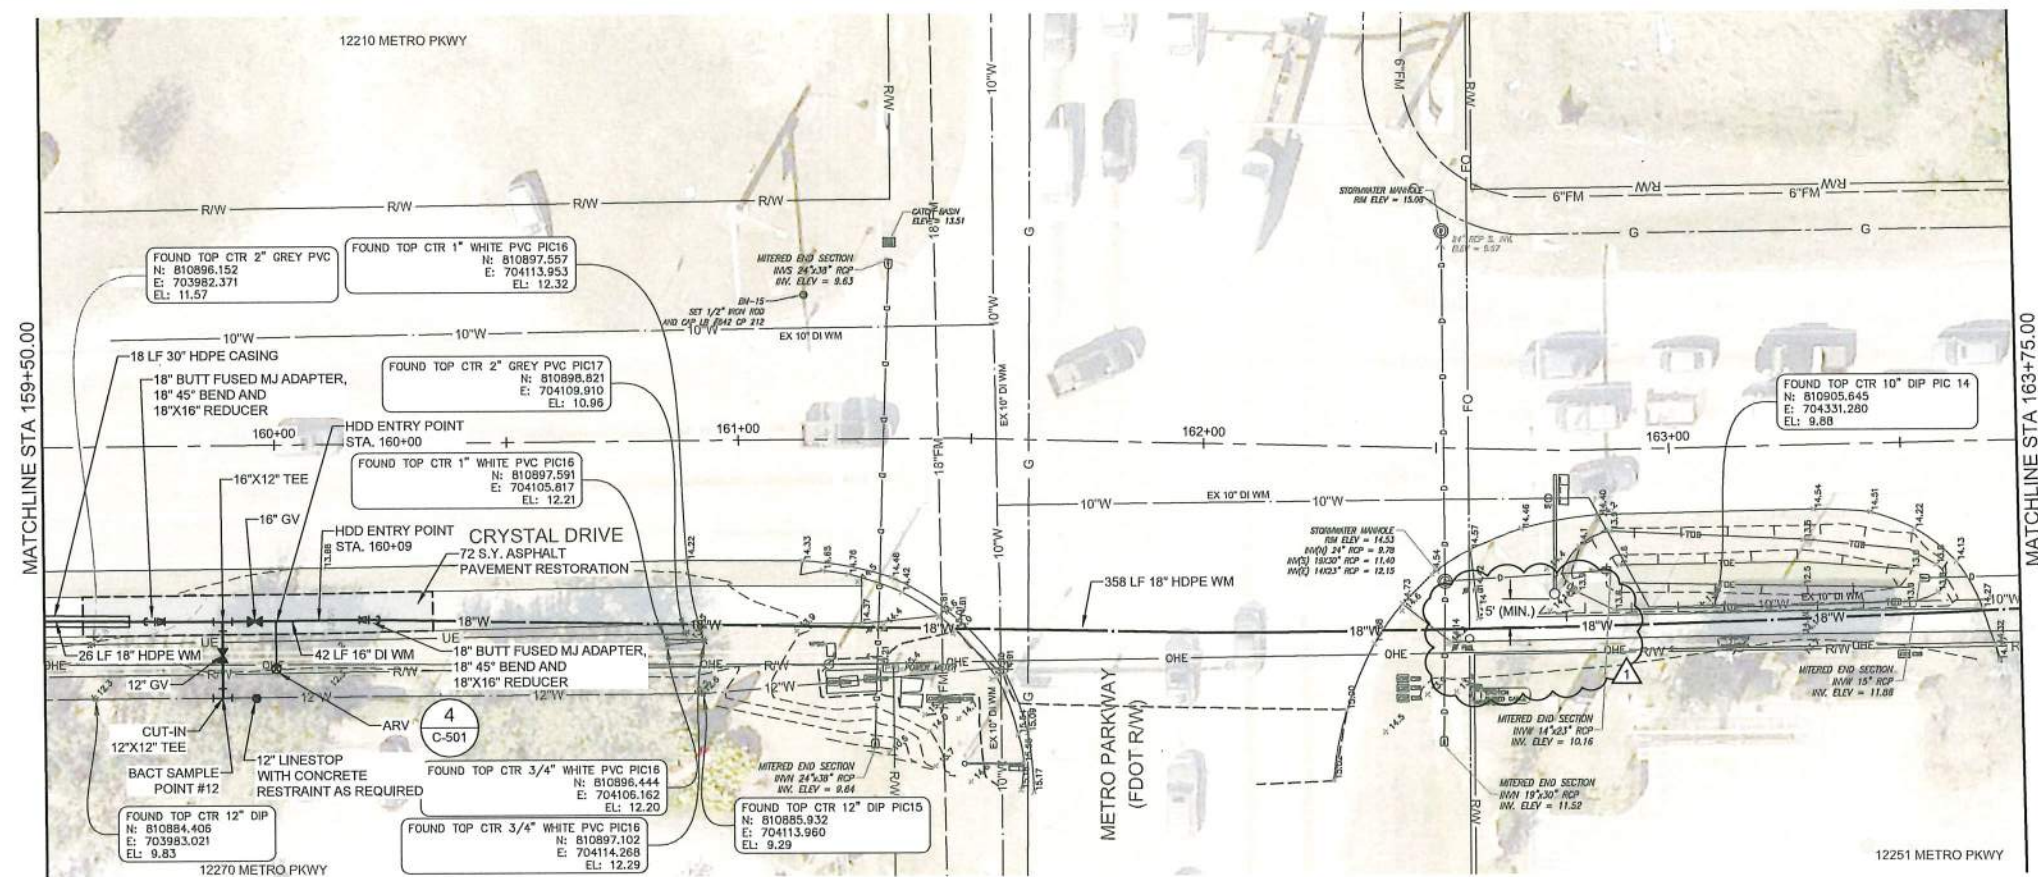

NOTE:
THE EXISTING DEPTH OF THE
4" GAS MAIN COULD NOT BE
VERIFIED DURING DESIGN.
CONTRACTOR SHALL MAKE ALL
EFFORTS POSSIBLE TO VERIFY
THE DEPTH OF THE EXISTING
GAS MAIN PRIOR TO
CONSTRUCTION USE EXTREME
CAUTION DURING DRILL
ACTIVITIES, COORDINATE ALL
ACTIVITIES W/ TEO.

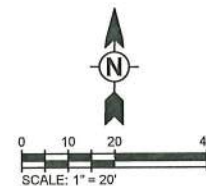

TETRA TECH

STEVEN AGAPI, P.E.
LICENSE #88612
Tetra Tech Inc.
0600 Chevrolet Way, Ste. 102
Estero, Florida 33928
Engineering Business No. 2429

10800 CHEVROLET WAY, SUITE 102
ESTERO, FL 33928
PHONE: (239) 390-1467 FAX: (407) 839-3790
www.telratech.com

DATE _____





MARK	DATE	DESCRIPTION	BY
1	07/13/20	FDOT COMMENT 05/28/2020	

LEE COUNTY UTILITIES
CRYSTAL DRIVE
WATER MAIN IMPROVEMENTS
CRYSTAL DRIVE
PLAN AND PROFILE

Project No.:	200-01558-1900
Designed By:	AS
Drawn By:	WV
Checked By:	AS




C-121

Bar Measures 1 inch

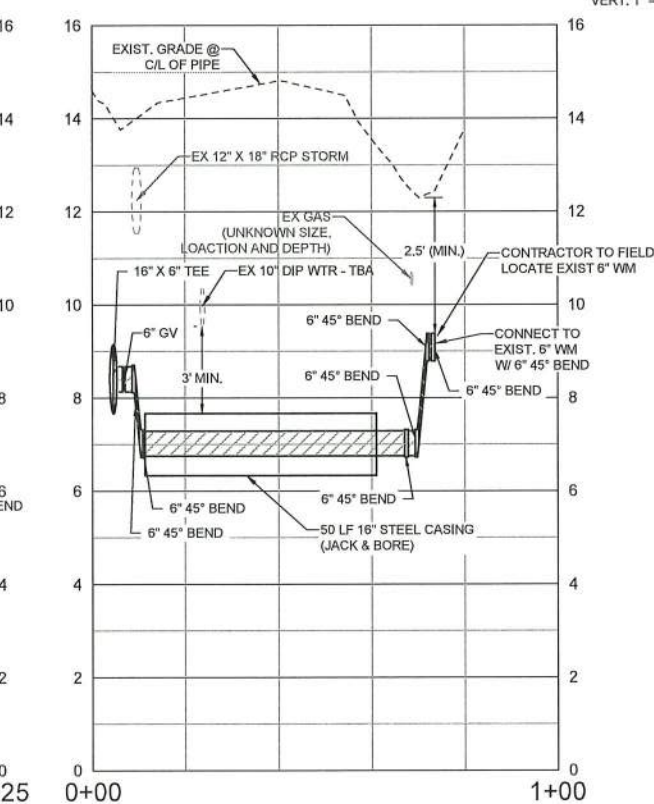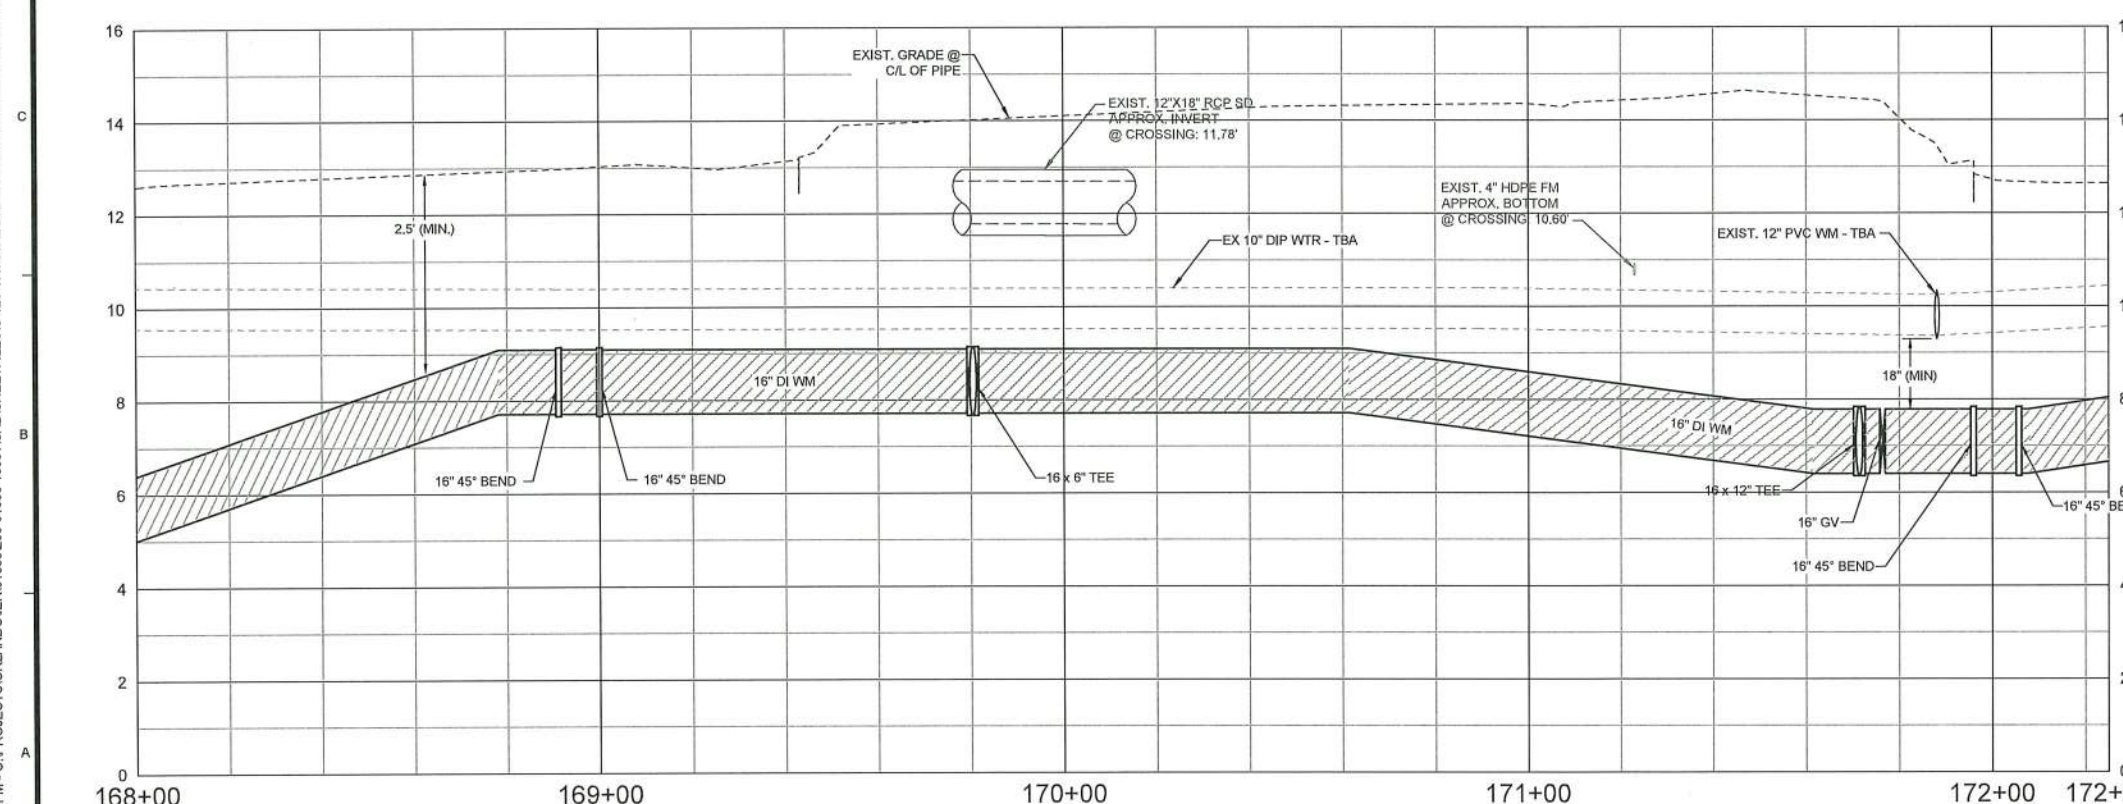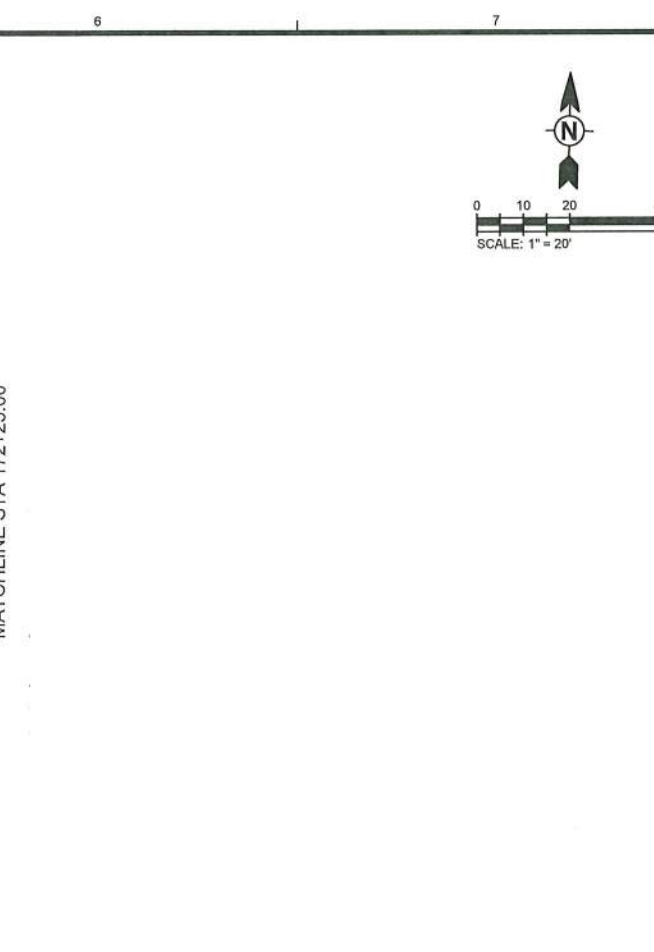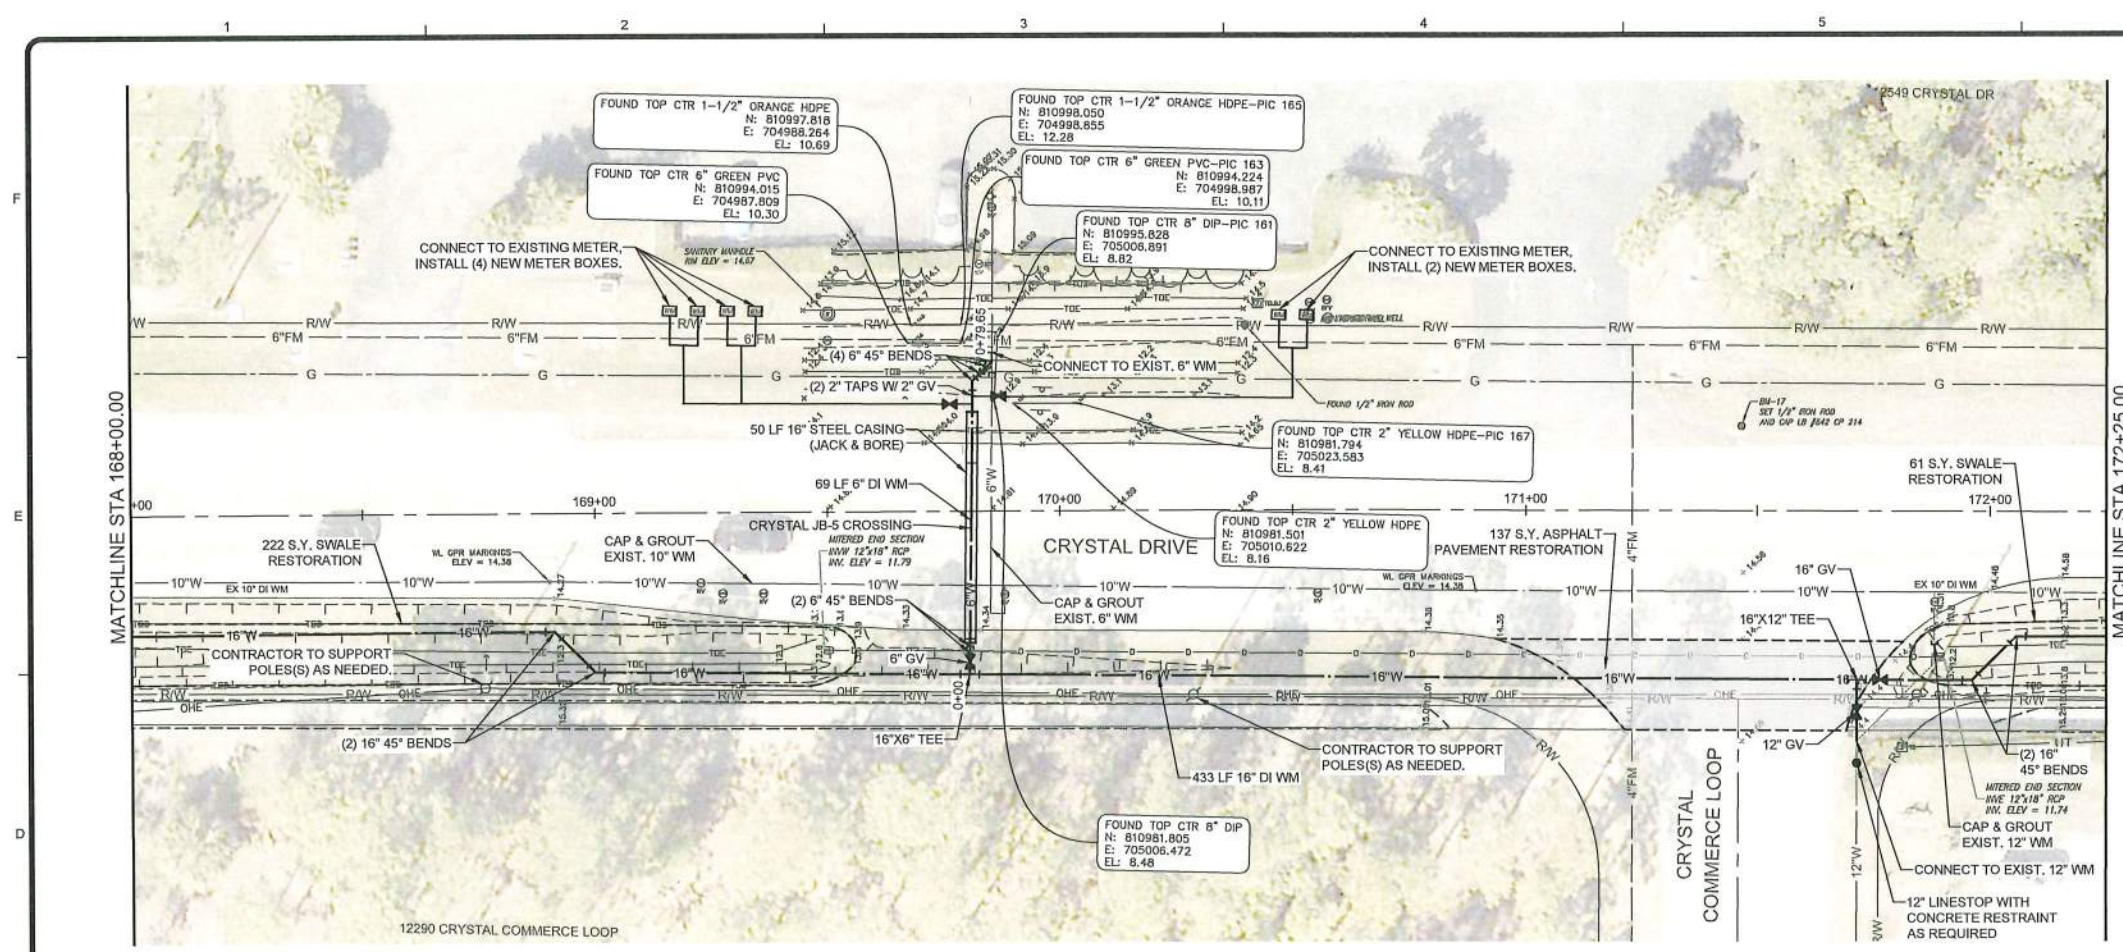

C-123					
Project No.: 200-01558-19001					
Designed By:		AS			
Drawn By:		WV			
Checked By:		AS			
LEE COUNTY UTILITIES CRYSTAL DRIVE WATER MAIN IMPROVEMENTS CRYSTAL DRIVE PLAN AND PROFILE		MARK	DATE	DESCRIPTION	BY
STEVEN AGAPI, P.E. LICENSE #88612 Tetra Tech Inc. 10600 Chevrolet Way, Ste. 102 Estero, Florida 33928 Engineering Business No. 2429		 TETRA TECH www.tetratech.com 10600 CHEVROLET WAY, SUITE 102 ESTERO, FL 33928 PHONE: (239) 390-1467 FAX: (407) 859-3790			
DATE _____					

7/15/2020 8:09:20 PM - C:\PROJECTS\ORLANDO\1558\200-01558-19001\CAD\1558-19001\CRYSTAL DRIVE PLAN AND PROFILE.DWG - CYR, STEVE

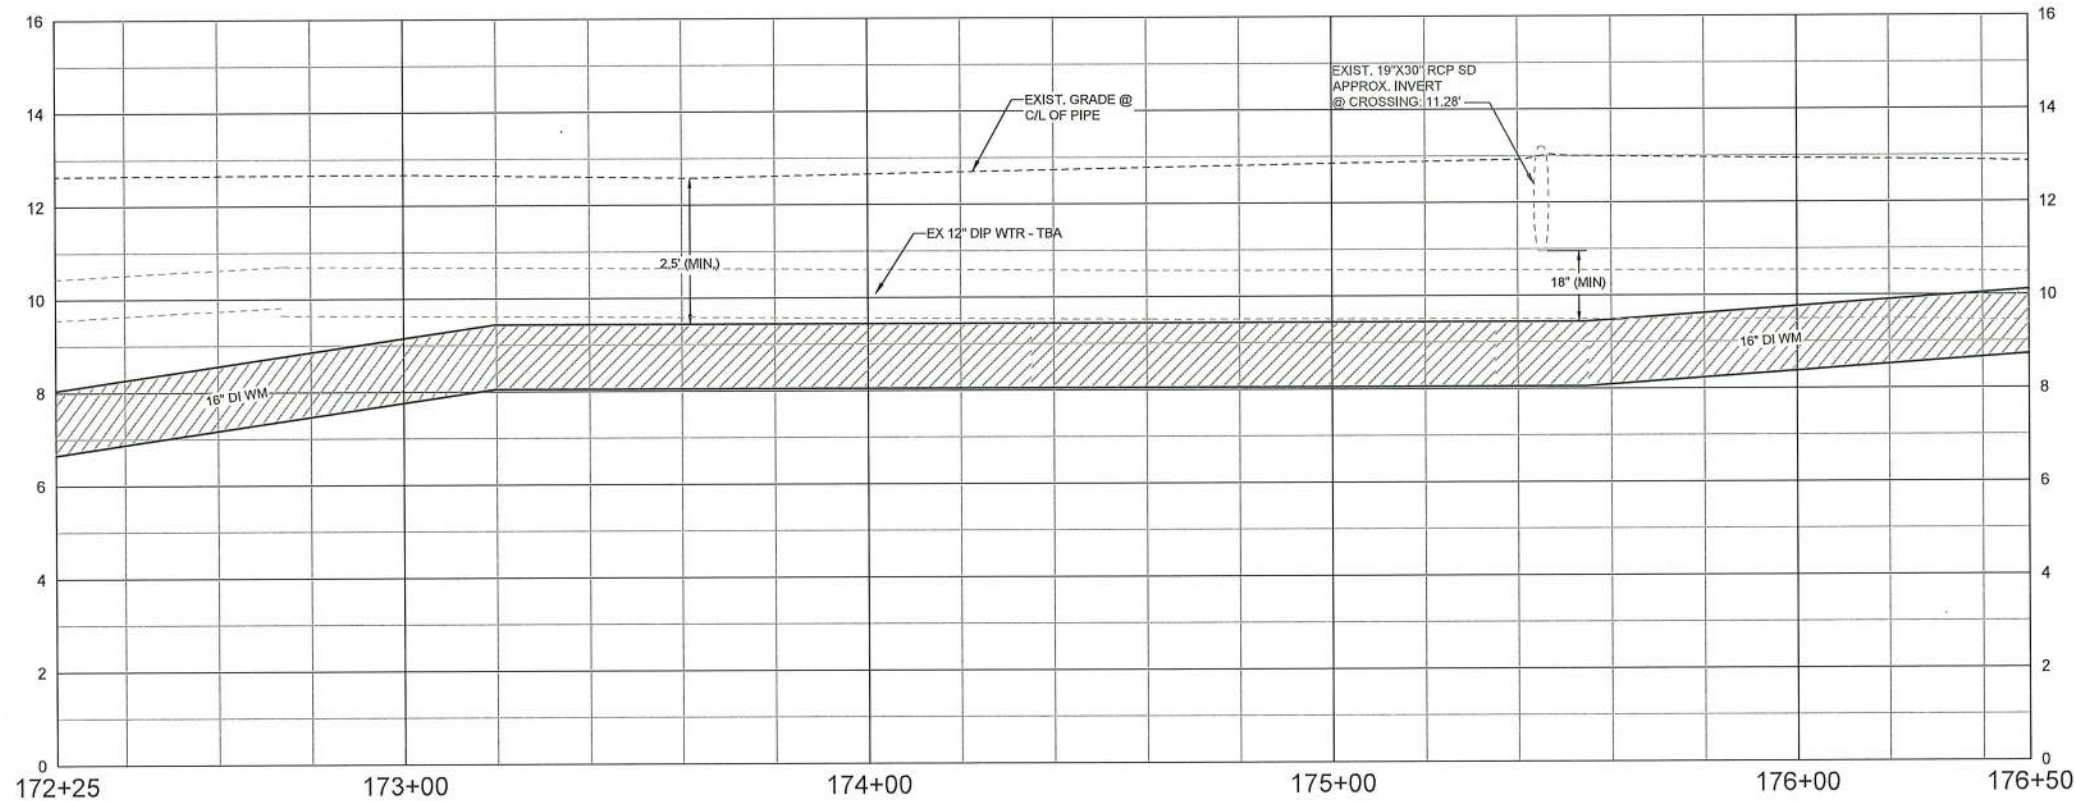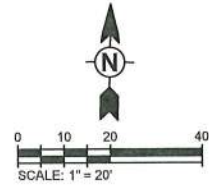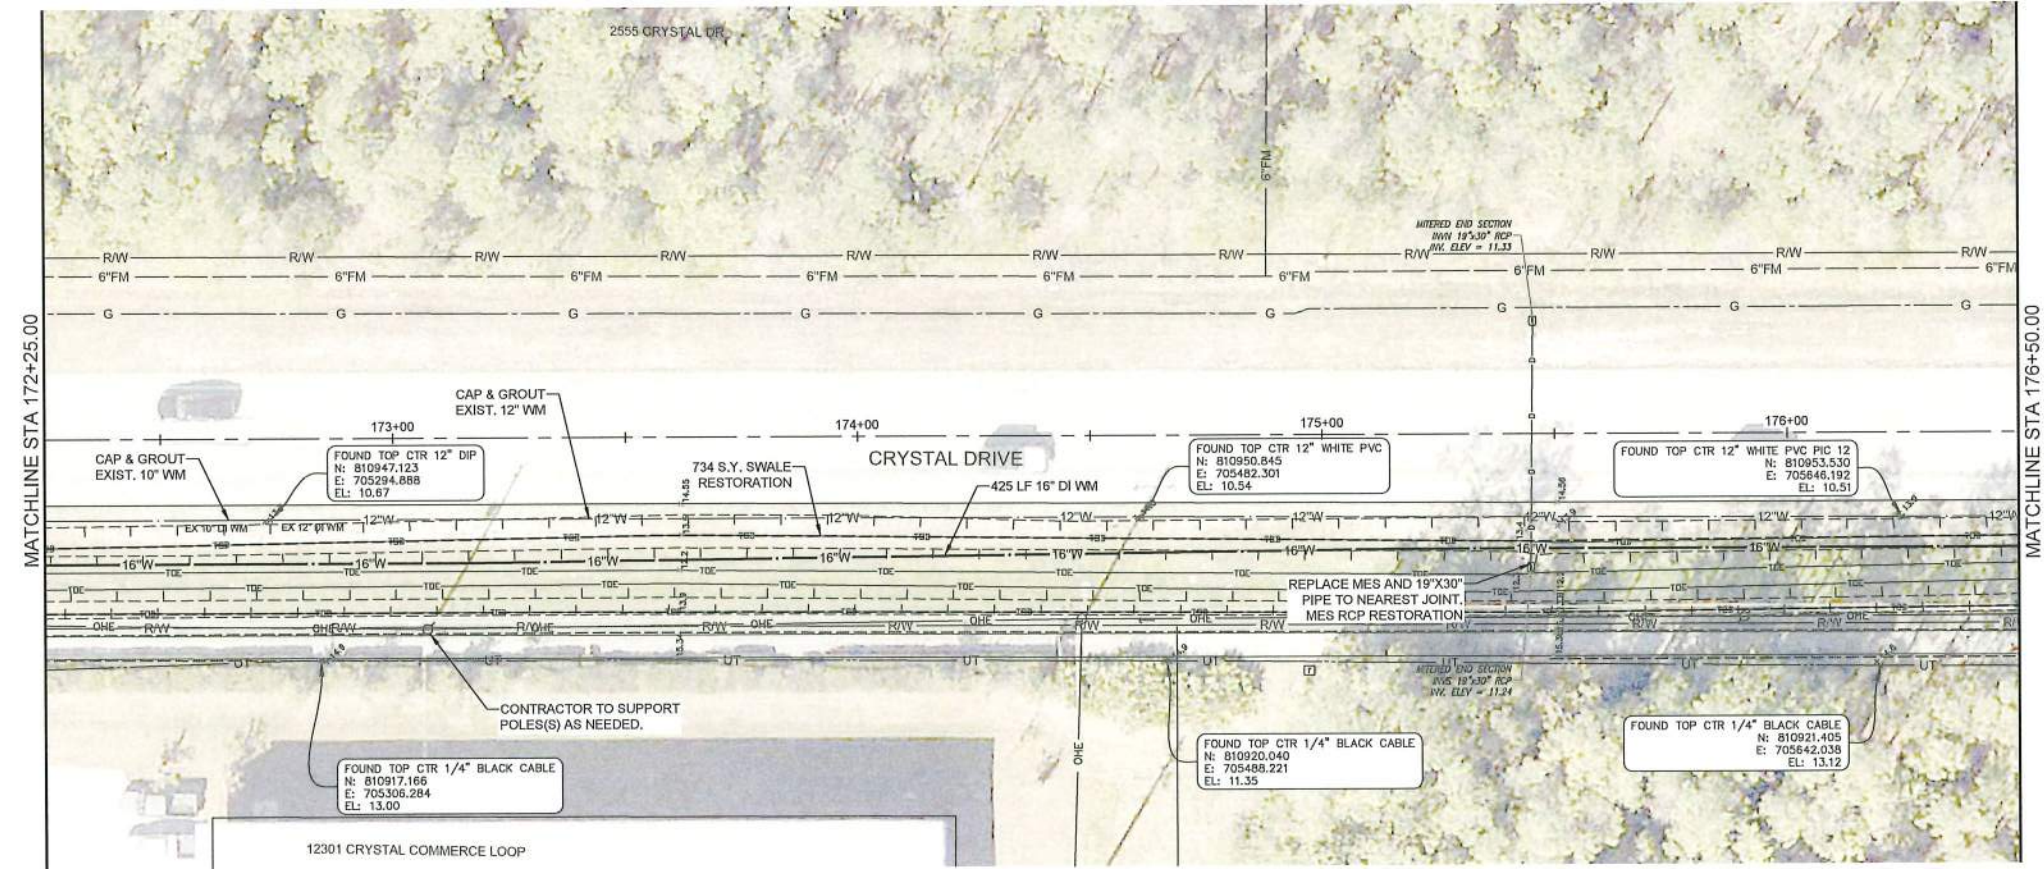

SCALE:
HORIZ. 1" = 20'
VERT. 1" = 2'



STEVEN AGAPI, P.E.
LICENSE #48812
Tetra Tech Inc.
10600 Chevrolet Way, Ste. 102
Estero, Florida 33928
Engineering Business No. 2429

www.tetrattech.com

10600 CHEVROLET WAY, SUITE 102
ESTERO, FL 33928
PHONE: (239) 390-1467 FAX: (407) 899-3790

MARK	DATE	DESCRIPTION	BY

LEE COUNTY UTILITIES
CRYSTAL DRIVE
WATER MAIN IMPROVEMENTS
CRYSTAL DRIVE
PLAN AND PROFILE

Project No.: 200-01558-19001
Designed By: AS
Drawn By: WV
Checked By: AS

C-124


Bar Measures 1 inch

Copyright: Tetra Tech

7/15/2020 8:16:23 PM - C:\PROJECTS\ORLANDOVER\01558\200-01558-19001\CAD\DETAILS\DWG - CYR, STEVE

LEE COUNTY UTILITY STANDARD DETAIL

STANDARD DETAIL NO. 6.1
LEE COUNTY UTILITIES
TAPPING SLEEVE AND VALVE

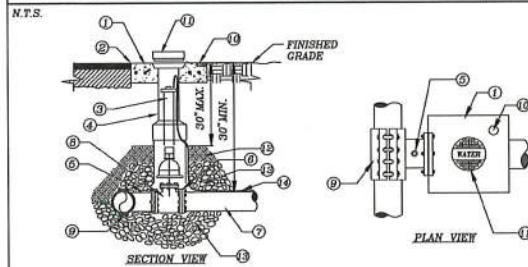


- 1 CONCRETE PAD (SEE VALVE INSTALLATION DETAIL)
- 2 SET TOP OF BOX FLUSH WITH FINISHED GRADE
- 3 EXTENSION STEM IF TOP OF OPERATING NUT IS MORE THAN 30" BELOW FINISH GRADE
- 4 VALVE BOX (SEE VALVE INSTALLATION DETAIL)
- 5 OUTLET FOR TESTING
- 6 MJ RESTRAINED
- 7 MAIN SIZE VARIES
- 8 TAPPING VALVE (SEE VALVE INSTALLATION DETAIL)
- 9 LCU APPROVED ALL STAINLESS STEEL PRESSURE RATED TAPPING SLEEVE. FOR SIZE ON SIZE TAPS A FLANGED TAPPING SLEEVE IS REQUIRED. SPRING LOADED TAPPING SLEEVE IS REQUIRED WHEN CONNECTING TO HDPE (SEE APPROVED MATERIAL LIST).
- 10 BRASS PLATE (SEE VALVE INSTALLATION DETAIL)
- 11 CAST IRON DROP COVER MARKED "WATER", "SEWER", OR "REUSE"
- 12 COMPACTED SUITABLE EARTH BACKFILL
- 13 3/4" GRANULAR MATERIAL #57 STONE
- 14 12 GAUGE DOUBLE INSULATED COPPER LOCATING WIRE (SEE LCU STANDARD DETAIL)

REV: 12/10/2015

1 DETAIL
SCALE: NTS

LEE COUNTY UTILITY STANDARD DETAIL

STANDARD DETAIL NO. 6.2
LEE COUNTY UTILITIES
VALVE INSTALLATION

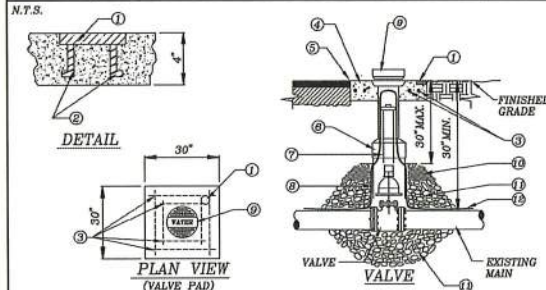


- 1 BRASS PLATE: SIZE OF VALVE, VALVE TYPE
No. OF TURNS & DIRECTION TO OPEN
VALVE M.F.G. & YEAR INSTALL
SYSTEM "WATER" OR "SEWER" OR "REUSE" OR "FIRE"
- 2 ANCHOR
- 3 EIGHT (8) #4 BARS OVERLAP EACH CORNER BY 2"
- 4 30" SQ X 4" THK. CONC. PAD SURROUNDING BOX, MIN.
3,000 P.S.I. POURED IN PLACE
- 5 SET TOP OF BOX FLUSH WITH FINISHED GRADE
- 6 HEAVY DUTY TRAFFIC BEARING CAST IRON VALVE BOX, ADJUSTABLE SCREW
TYPE, 5 1/4" DIAMETER SHAFT THAT IS LCU APPROVED
- 7 EXTENSION STEM WITH 2" OPERATING NUT AS REQUIRED, IF NUT IS
MORE THAN 30" BELOW FINISH GRADE
- 8 RISER NOT TO BEAR ON VALVE OR PIPE
- 9 CAST IRON DROP COVER MARKED "WATER" OR "SEWER" OR "REUSE" OR "FIRE"
- 10 COMPACTED SUITABLE EARTH BACKFILL
- 11 3/4" GRANULAR MATERIAL #57 STONE
- 12 12 GAUGE DOUBLE INSULATED COPPER LOCATING WIRE (SEE LCU STANDARD DETAIL)

REV: 12/10/2015

2 DETAIL
SCALE: NTS

LEE COUNTY UTILITY STANDARD DETAIL

STANDARD DETAIL NO. 6.3
LEE COUNTY UTILITIES
LOCATING WIRE FOR PRESSURE MAINS

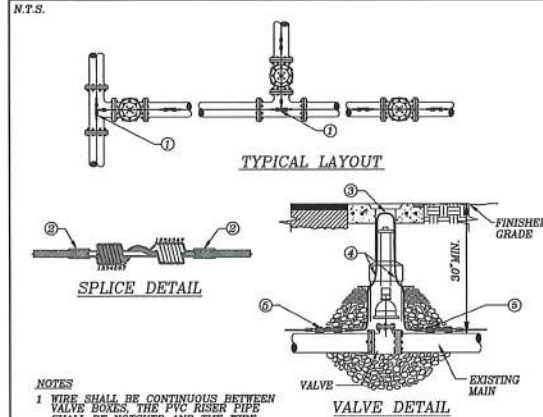

NOTES


- 1 WIRE SHALL BE CONTINUOUS BETWEEN VALVE BOXES. THE PVC RISER PIPE SHALL BE NOTCHED AND THE WIRE ATTACHED TO THE RISER PIPE TO ALLOW FOR THE WIRE TO FIT INSIDE THE CAST IRON VALVE BOX WITHOUT SHEARING THE WIRE.
- 2 LOCATING WIRE SHALL BE LAID ON TOP OF THE MAIN AND SHALL BE TAPED TO IT AT 10' INTERVALS AND TAPED AT ALL FITTINGS. TAPES SHALL BE 10 MIL. POLYETHYLENE.
- 3 CONTRACTOR SHALL CONDUCT A CONTINUITY TEST ON ALL LOCATING WIRE SPLICES PRIOR TO SCHEDULING THE OFFICIAL FINAL INSPECTION WITH LCU.
- 4 ALL SPLICES SHALL UTILIZE A DIRECT RURY WATERPROOF SPLICE KIT (SEE APPROVED MATERIAL LIST)
- 5 SPLICE RUN TOGETHER, KEEP CLEAR OF FITTING, TYPICAL
- 6 COVER SPLICE WITH 2 WRAPS OF 10 MIL. POLYETHYLENE TAPE
- 7 6" LOOP OF BARE WIRE, 9" MAX. DEPTH TO TOP OF BARE WIRE
- 8 12 GAUGE DOUBLE INSULATED COPPER LOCATING WIRE
- 9 SPLICE (SEE DETAIL THIS SHEET)

REV: 12/10/2015

3 DETAIL
SCALE: NTS

LEE COUNTY UTILITY STANDARD DETAIL

STANDARD DETAIL NO. 6.4
LEE COUNTY UTILITIES
AUTOMATIC AIR RELEASE VALVE

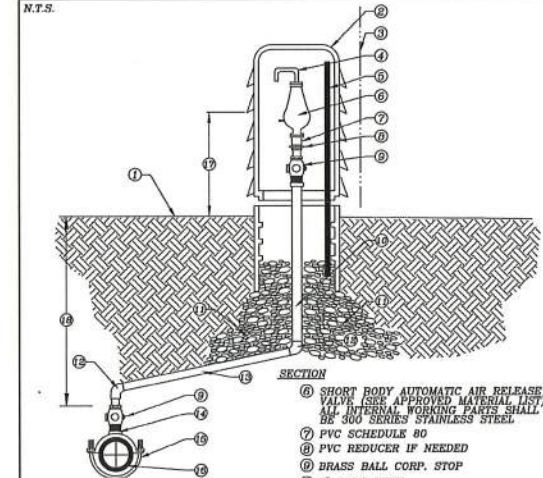


- 1 FINISHED GRADE
- 2 PEDestal HOUSING (SEE APPROVED MATERIAL LIST)
COLORS: BLUE-WATER
GREEN-SEWER, PANTONE-REUSE
- 3 EDGE OF RIGHT-OF-WAY
- 4 PVC STREET ELL
- 5 S.S. POST WITH S.S. HARDWARE AND S.S. LOCKING HASP WITH BRASS LOCK
- 6 SHORT BODY AUTOMATIC AIR RELEASE VALVE (SEE APPROVED MATERIAL LIST)
ALL INTERNAL WORKING PARTS SHALL BE 300 SERIES STAINLESS STEEL
- 7 PVC SCHEDULE 80
- 8 PVC REDUCER IF NEEDED
- 9 BRASS BALL CORP. STOP
- 10 2" POLY-TUBE
- 11 3/4" GRANULAR MATERIAL #57 STONE
- 12 2" BRASS FITTING IF NECESSARY
- 13 1% MIN. SLOPE UP, 2" POLY-TUBE
- 14 TAP AT CROWN OF PIPE
- 15 2" TAPPING SADDLE, 3416AS
- 16 EXISTING PRESSURE MAIN
- 17 24"
- 18 30" MIN.

REV: 12/10/2015

4 DETAIL
SCALE: NTS

LEE COUNTY UTILITY STANDARD DETAIL

STANDARD DETAIL NO. 6.5
LEE COUNTY UTILITIES
TRENCH CROSS SECTION

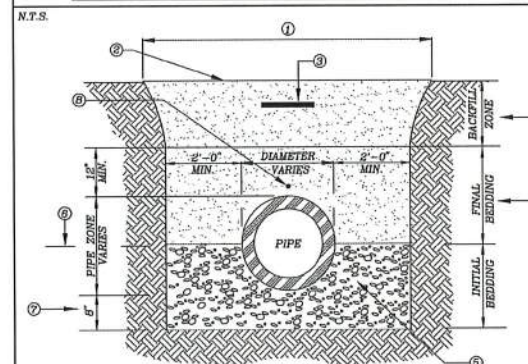


- 1 EXCAVATED TRENCH
- 2 FINISHED GRADE
- 3 MARKING TAPE 12" DEPTH MAX.
- 4 MATERIALS CLEAN DRY SAND, FINE LIME ROCK OR PIT SHEL MECHANICALLY COMPACTED IN 6" LIFTS TO AT LEAST 95% OF MAX. DENSITY, OR 98% IF UNDER PAVED AREA OF ROADWAY.
- 5 #57 STONE LOCATED UNDER PIPE OR EXISTING UNDISTURBED SUITABLE MATERIAL
- 6 SPRING LINE
- 7 STANDARD 6" MIN TRENCH UNDERCUT AND BACKFILL WITH #57 STONE COMPACTED IN 6" LIFTS ADDITIONAL UNDERCUT AND CRUSHED ROCK BEDDING FOUNDATION WHEN DIRECTED BY LCU. THE CONTRACTOR IS TO REMOVE UNSTABLE MATERIAL FROM THE TRENCH FOUNDATION. THEN INSTALL STABILIZED CRUSHED ROCK BACKFILL WITH #57 STONE COMPACTED IN 6" LIFTS
- 8 LOCATING WIRE IS REQUIRED FOR ALL PRESSURIZED PIPELINES.

REV: 12/10/2015

5 DETAIL
SCALE: NTS

LEE COUNTY UTILITY STANDARD DETAIL

STANDARD DETAIL NO. 6.6
LEE COUNTY UTILITIES
JACK AND BORE

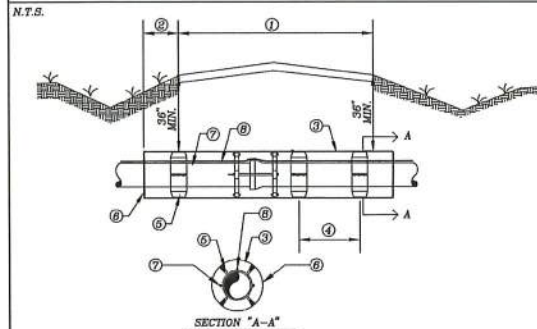


- 1 LIMITS OF PAVEMENT
- 2 EXTEND CASING 4' MIN. BEYOND E.O.P. AND/OR BACK OF CURB FOR L.C.D.O.T. MAINTAINED R.O.W. AND 8' MIN. FOR F.D.O.T. MAINTAINED R.O.W.
- 3 STEEL CASING PIPE CONFORMING TO ASTM A-139
- 4 T.O.C. MAX OR AS PER MANUFACTURER'S RECOMMENDATION
- 5 L.C.U. APPROVED CASING SPACERS
- 6 SEAL CASING ENDS WITH: 8" WALL OF BRICK MASONRY WITH TIEBOLTS INSTALLED NEAR BOTTOM, OR APPROVED EQUAL
- 7 ALL JOINTS OF THE CARRIER PIPE SHALL HAVE BELL RESTRAINTS
- 8 12 GAUGE DOUBLE INSULATED COPPER WIRE (SEE LCU STANDARD DETAIL)

REV: 12/10/2015

6 DETAIL
SCALE: NTS

LEE COUNTY UTILITY STANDARD DETAIL

STANDARD DETAIL NO. 6.7
LEE COUNTY UTILITIES
HORIZONTAL DIRECTIONAL DRILL UNDER A ROADWAY

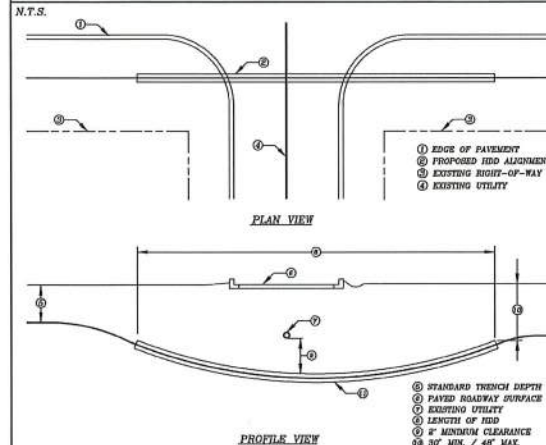

HDD INSTALLATION NOTES:


1. ALL WORK SHALL BE IN ACCORDANCE WITH THE LCU COUNTY UTILITIES DESIGN MANUAL.
2. THE CONTRACTOR SHALL BE RESPONSIBLE FOR NOTIFICATION OF AFFECTED AGENCIES AND COORDINATION WITH ALL UTILITIES PRIOR TO CONSTRUCTION.
3. ALL CONSTRUCTION MATERIALS INCLUDING GRADING PLANS, SHALL BE REMOVED FROM THE SITE PRIOR TO RESTORATION OF DISTURBED AREAS.
4. ALL RESTORATION WORK SHALL BE IN ACCORDANCE WITH THE LCU DESIGN MANUAL.
5. STANDARD TRENCH DEPTH
6. PAVED ROADWAY SURFACE
7. EXISTING UTILITY
8. LENGTH OF HDD
9. 6" MINIMUM CLEARANCE
10. 80' MIN. / 40' MAX.
11. PROPOSED HDD ALIGNMENT
12. CASING DIAMETER SHALL BE IN ACCORDANCE WITH THE LCU DESIGN MANUAL.
13. NO CASING SPACERS REQUIRED.
14. WHEN CASING IS REQUIRED INITIAL 1" HOPE PIPE ATTACHED TO THE CARRIER PIPE WITH 12 GAUGE DOUBLE INSULATED COPPER WIRE INSIDE THE HOPE PIPE.

REV: 12/10/2015

7 DETAIL
SCALE: NTS

LEE COUNTY UTILITY STANDARD DETAIL

STANDARD DETAIL NO. 6.8
LEE COUNTY UTILITIES
WATER AND SEWER CROSSING DETAIL

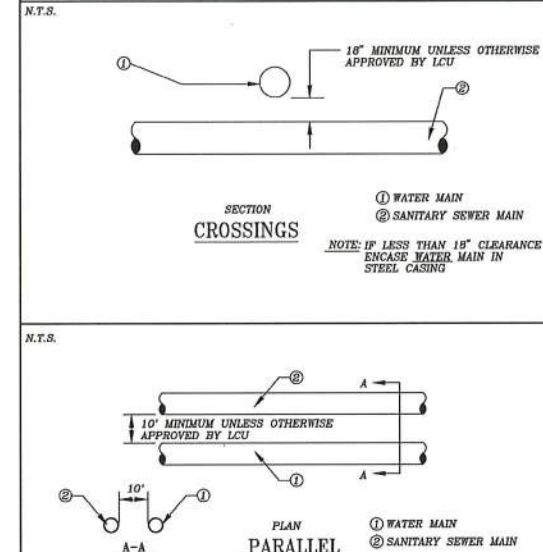

- 1 WATER MAIN
 - 2 SANITARY SEWER MAIN
- NOTE: IF LESS THAN 10' CLEARANCE ENCASE WATER MAIN IN STEEL CASING

REV: 12/10/2015

8 DETAIL
SCALE: NTS

TETRA TECH



STEVEN AGAPI, P.E.
LICENSE #88612
Tetra Tech Inc.
10600 Chevrolet Way, Ste. 102
Estero, Florida 33928
Engineering Business No. 2429

DATE

BY

MARK

DATE

DESCRIPTION

LEE COUNTY UTILITIES

CRYSTAL DRIVE

WATER MAIN IMPROVEMENTS

CIVIL DETAILS

Project No.: 200-01558-19001

Designed By: AS

Drawn By: WV

Checked By: AS

C-501

Bar Measures 1 inch

100


STANDARD DETAIL NO. 6.19
LEE COUNTY UTILITIES
3/4" TO 2" CROSS CONNECTION CONTROL ASSEMBLY



REV: 12/10/2015

1 DETAIL
SCALE: NTS

STANDARD DETAIL NO. 6.24
LEE COUNTY UTILITIES
FIRE HYDRANT ASSEMBLY

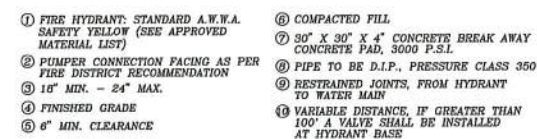

REV: 12/10/2015

2 DETAIL
SCALE: NTS

STANDARD DETAIL NO. 6.25
LEE COUNTY UTILITIES
FIRE HYDRANT LOCATIONS/CLEARANCE



3 DETAIL
SCALE: NTS

REMOVE A MIN. OF 3' UPSTREAM FROM POINT REPAIR OR TO NEXT STRUCTURALLY ADEQUATE JOINT.

LIMITS OF OPEN CUT REPAIR

REPLACEMENT PIPE SHALL BE PVC

REMOVE A MIN. OF 3' DOWNSTREAM FROM POINT REPAIR OR TO NEXT STRUCTURALLY ADEQUATE JOINT.


FLOW

EXISTING V.C.

FERRO CONECTOR (TYP.)

4 DETAIL
SCALE: NTS

DIMENSIONS AND QUANTITIES													54' CONCRETE SLAB (C7) □				SODDING (SY)						
													M										
D	X	A	B	C	E	F	G	H □	Single				N ₁	Single				N ₂	Single				
									Pipe	Double	Tripla	Qued.		Pipe	Double	Tripla	Qued.		Pipe	Double	Tripla	Qued.	
1/2 Slope	19'	2-1"	1.89	2.18	4.19	2.00	9	1.32	2.9	4.82	7.39	10.58	15.42	1.19	1.12	0.44	0.65	0.77	1.05	23	27	30	31
	20'	2-10"	1.97	2.14	4.11	2.00	6	1.41	3	4.82	7.39	10.58	15.42	1.21	0.44	0.65	0.87	1.09	22	25	28	31	
	22'	3-0"	2.00	3.89	5.91	3.50	7	1.73	3.0	5.50	8.92	12.39	15.79	1.29	0.54	0.83	1.12	1.42	24	28	32	35	
	30'	4-0"	2.19	4.05	7.10	4.50	8	2.00	3.0	6.08	10.32	14.58	18.83	1.29	0.68	1.09	1.50	1.91	26	31	35	40	
	36'	5-1"	2.27	4.06	8.13	5.50	9	2.27	3.0	6.42	10.32	14.58	18.83	1.31	0.81	1.21	1.62	2.13	28	34	39	45	
	42'	6-0"	2.34	7.21	9.59	6.50	10	2.43	3.0	7.23	12.39	19.29	25.29	1.39	0.97	1.70	2.45	3.91	30	37	43	50	
	48'	6-0"	2.43	8.33	10.76	7.00	11	2.69	3.0	7.83	14.58	21.33	28.00	1.42	1.13	2.05	3.04	32	39	47	54		
	54'	6-0"	2.57	9.44	11.68	8.50	12	2.95	3.0	8.43	16.73	23.31	30.31	1.44	1.24	2.48	4.23	34	42	51	59		
	60'	6-0"	2.65	10.50	13.10	9.50	13	3.00	4.0	9.07	17.50	26.00	34.50	1.50	1.51	2.80	4.28	3.68	38	45	55	64	
	1/4 Slope	19'	2-7"	1.16	11.68	14.39	10.50	19	3.18	4.0	9.58	17.75	27.92	37.50	1.54	1.68	3.25	4.84	6.43	38	48	58	68
22'		3-0"	1.20	12.00	15.60	11.50	20	3.40	4.0	10.10	20.10	30.10	40.10	1.58	1.69	3.48	5.08	6.74	40	50	60	71	
24'		3-10"	1.27	4.09	6.36	4.03	12	4.0	4.0	10.58	20.10	30.10	40.10	1.59	1.79	3.57	5.37	7.17	41	51	61	72	
26'		2-10"	1.30	5.12	7.49	5.03	9	1.41	4.0	4.52	7.39	10.58	13.77	1.19	0.57	0.87	1.15	1.44	23	26	29	32	
28'		3-0"	2.53	7.19	9.71	7.01	11	1.77	4.0	5.50	8.92	12.39	15.79	1.29	0.85	1.30	1.75	2.30	28	32	36	40	
30'		3-10"	2.92	9.29	11.85	9.03	12	2.00	4.0	6.08	10.32	14.58	18.83	1.29	1.03	1.74	2.39	3.03	31	35	40	45	
36'		5-1"	2.87	11.31	14.18	11.02	9	2.24	4.0	6.67	12.39	18.83	25.32	1.39	1.32	2.21	3.08	3.98	34	40	46	52	
42'		6-0"	3.03	13.37	16.42	13.03	17	2.49	4.0	7.23	13.29	19.29	25.29	1.39	1.50	2.76	3.91	5.09	34	44	51	58	
48'		6-0"	3.22																				

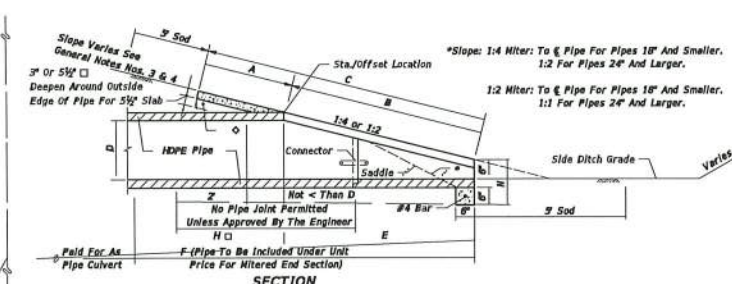


5 DETAIL
SCALE: NTS


PER FDOT INDEX # 430-021
PER FDOT SPECIFICATIONS 430

NOTES FOR REPLACEMENT URBAN FLARED TURNOUTS

1. DRIVEWAY 6" CONCRETE PAVEMENT AND DROP CURB SHALL MEET THE MATERIAL AND CONSTRUCTION REQUIREMENTS OF SECTIONS 522 AND 520 RESPECTIVELY OF THE FDOT STANDARD SPECIFICATIONS. THE DRIVEWAY FOUNDATION SHALL MEET THE REQUIREMENT OF SUBARTICLE 522-4.
2. DRIVEWAYS AND DRIVEWAY APRONS SHALL BE 6" INCHES THICK, CLASS B CONCRETE, WITH 6X6-10/10 WWM, 3000 PSI MIN.
3. DRIVEWAY SHALL CONFORM WITH FDOT STANDARD INDEX NO. 515.
4. "X" JOINTS SHALL BE CONSTRUCTED WITH PREFORMED JOINT FILLER MATERIAL.

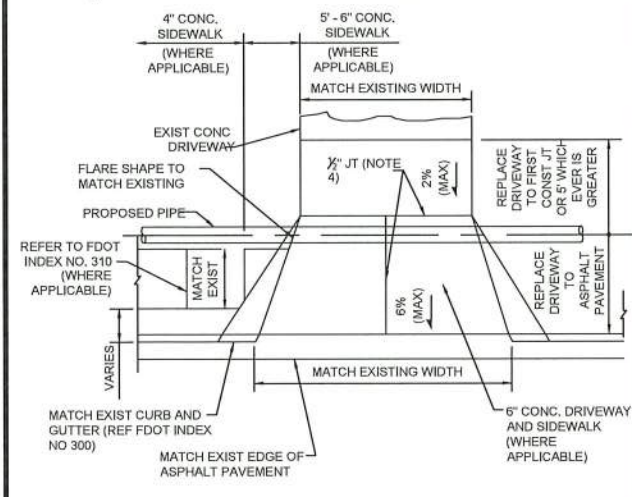

6 DETAIL
SCALE: NTS

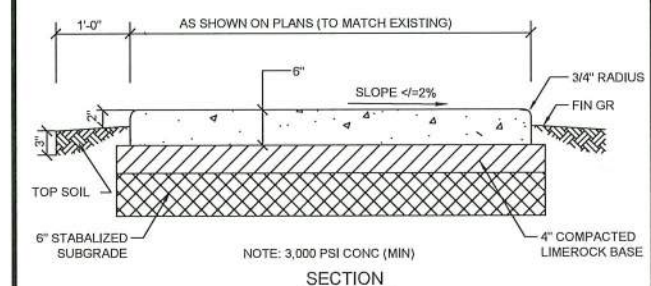

8 DETAIL
SCALE: NTS



TETRA TECH

STEVEN AGAPI, P.E.
LICENSE #88612
Tetra Tech Inc.
0600 Chevrolet Way, Ste. 102
Estero, Florida 33928
Engineering Business No. 2429

10600 CHEVROLET WAY, SUITE 102
ESTERO, FL 33928
PHONE: (239) 390-1467 FAX: (407) 839-3790
www.tetrattech.com

DATE .

MARK	DATE	DESCRIPTION	BY
1	07/13/20	LDO COMMENT 06/16/2020	

LEE COUNTY UTILITIES
CRYSTAL DRIVE
WATER MAIN IMPROVEMENTS
CIVIL DETAILS


Project No.:	200-01558-19001
Designed By:	AS
Drawn By:	WV
Checked By:	AS

C-503

Bar Measures 1 inch


Copyright: Tetra Tech

SILT FENCE

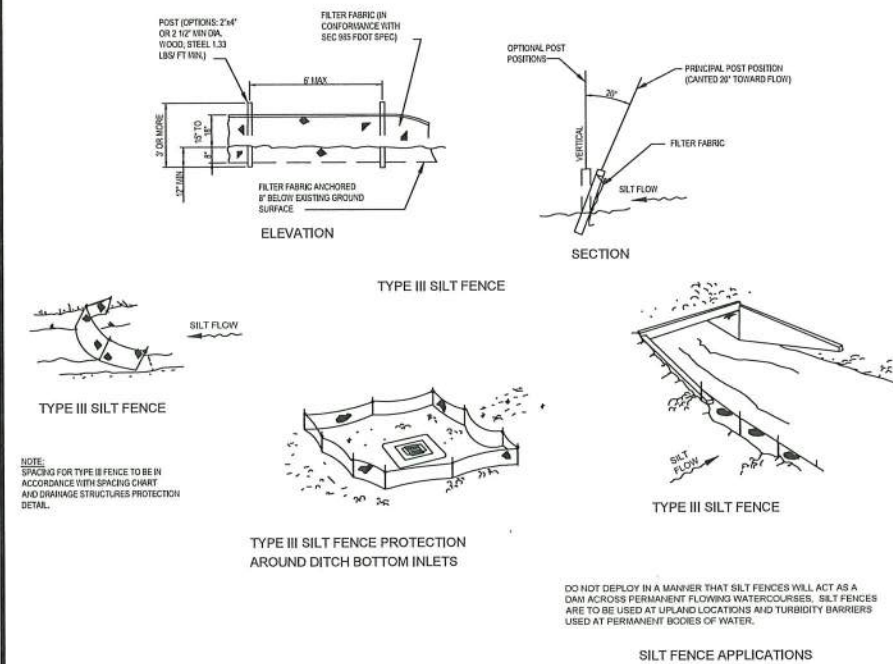


1 DETAIL
SCALE: NTS

INLET PROTECTION

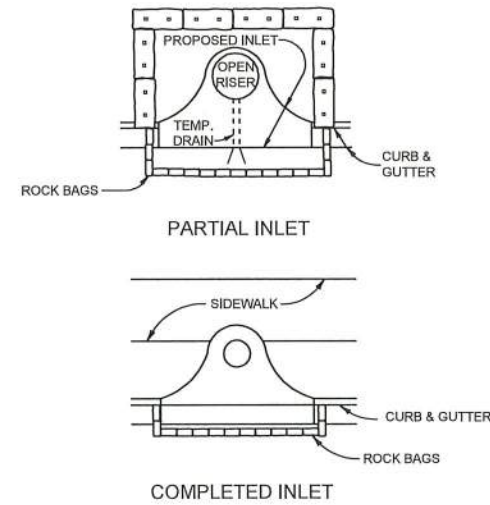


2 DETAIL
SCALE: NTS

BACTERIA SAMPLE POINT

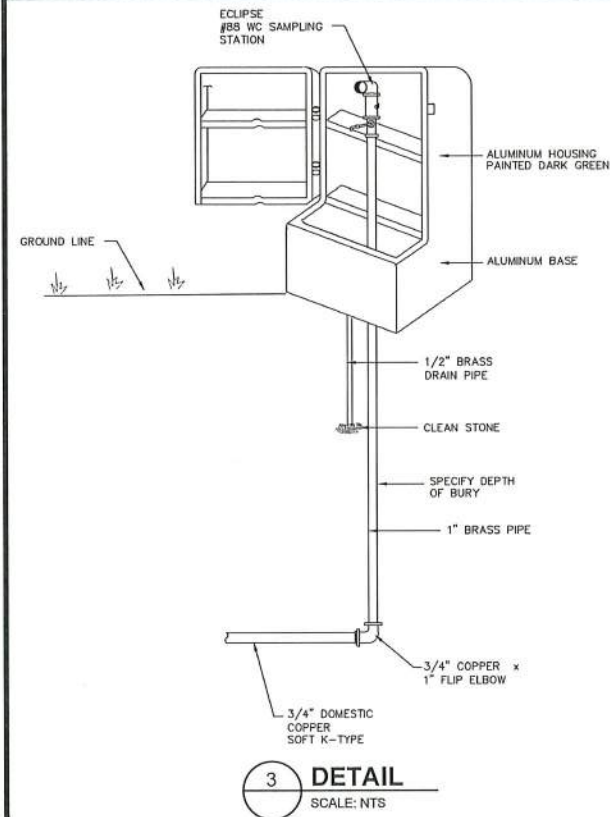

3 DETAIL
SCALE: NTS

PAVEMENT RESTORATION DETAIL

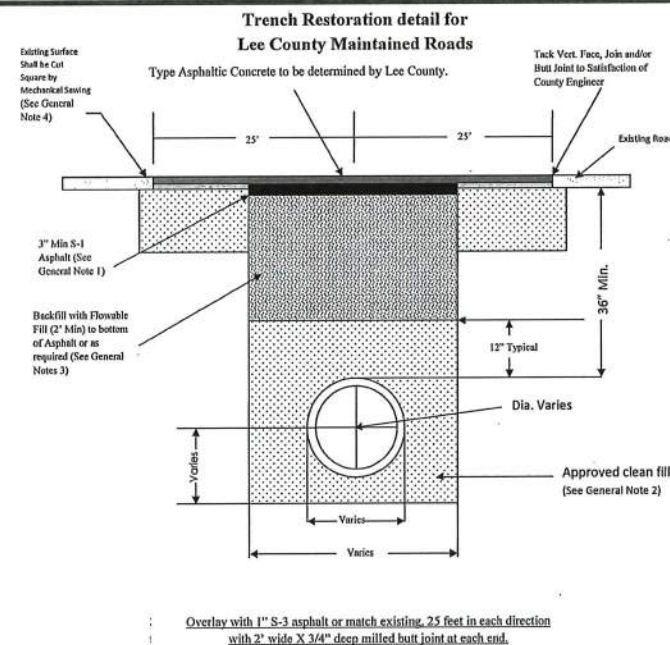

General Notes

1. The limits of Asphalt (overlay) replacement shall be determined by Lee County
2. For gravity pipe lines, may use rock 1' (R) above pipe per FDOT specifications.
3. Controlled Low Strength Materials (CLSM)
4. Using a 3/4" Thick X 4' Wide Butt Joint at Each End
5. Compaction must be performed in 6" lifts with densities every 12"

4 **DETAIL**
SCALE: NTS

TETRA TECH



STEVEN AGAPI, P.E.
LICENSE #88612
Tetra Tech Inc.
10600 Chevrolet Way, Ste. 102
Estero, Florida 33928
Engineering Business No. 2429

1

[illegible]

LEE COUNTY UTILITIES
CRYSTAL DRIVE
WATER MAIN IMPROVEMENTS
EROSION CONTROL
DETAILS

Project No.:	200-01558-19001
Designed By:	AS
Drawn By:	WV
Checked By:	AS

C-504

ar Measures 1 inch

7/15/2020 8:19:23 PM - O:\PROJECTS\ORLANDO\1558-200-01558-19001\CAD\ISHEETFILES\C-504 SUE PICTURES.DWG - CYR, STEVE

SUE PICTURE 1



SUE PICTURE 2



SUE PICTURE 3



SUE PICTURE 4



SUE PICTURE 5



SUE PICTURE 6



SUE PICTURE 7



SUE PICTURE 8



SUE PICTURE 9



SUE PICTURE 10



SUE PICTURE 11



SUE PICTURE 12



SUE PICTURE 13



SUE PICTURE 14



SUE PICTURE 15



SUE PICTURE 16



SUE PICTURE 17



SUE PICTURE 18



SUE PICTURE 19



SUE PICTURE 20



STEVEN AGAPI, P.E.
LICENSE #88612
Tetra Tech Inc.
10800 Chevrolet Way, Ste. 102
Estero, Florida 33928
Engineering Business No. 2429

10800 CHEVROLET WAY, SUITE 102
ESTERO, FL 33928
PHONE: (239) 390-1487 FAX: (407) 839-3790

DATE

MARK	DATE	DESCRIPTION	BY

LEE COUNTY UTILITIES
CRYSTAL DRIVE
WATER MAIN IMPROVEMENTS
SOFT DIG PICTURES

Project No.: 200-01558-19001
Designed By: AS
Drawn By: WV
Checked By: AS

C-504

Copyright: Tetra Tech

Bar Measures 1 inch

7/15/2020 8:20:58 PM - C:\PROJECTS\ORLANDO\1558\200-01558-19001\CAD\SHEETFILES\C-506 SUE PICTURES.DWG - CYR, STEVE

SUE PICTURE 21



SUE PICTURE 22



SUE PICTURE 23



SUE PICTURE 24



SUE PICTURE 25



SUE PICTURE 26



SUE PICTURE 27



SUE PICTURE 28



SUE PICTURE 29



SUE PICTURE 30



SUE PICTURE 31



SUE PICTURE 32



SUE PICTURE 33



SUE PICTURE 34



SUE PICTURE 35



SUE PICTURE 36



SUE PICTURE 37



SUE PICTURE 38



SUE PICTURE 39



SUE PICTURE 40



STEVEN AGAPI, P.E.
LICENSE #88912
Tetra Tech Inc.
10800 Chevrolet Way, Ste. 102
Estero, Florida 33928
Engineering Business No. 2429

www.tetrattech.com
10800 CHEVROLET WAY, SUITE 102
ESTERO, FL 33928
PHONE: (239) 390-1467 FAX: (407) 839-3790

DATE

MARK	DATE	DESCRIPTION

LEE COUNTY UTILITIES
CRYSTAL DRIVE
WATER MAIN IMPROVEMENTS
SOFT DIG PICTURES

Project No.: 200-01558-19001
Designed By: AS
Drawn By: WV
Checked By: AS

C-506

Copyright: Tetra Tech

Bar Measures 1 inch

7/15/2020 8:22:28 PM - C:\PROJECTS\ORLANDO\1558\200-01558-19001\CAD\ISHEETFILES\C-507 SUE PICTURES.DWG - CYR, STEVE

SUE PICTURE 41



SUE PICTURE 42



SUE PICTURE 43



SUE PICTURE 44



SUE PICTURE 45



SUE PICTURE 46



SUE PICTURE 47



SUE PICTURE 48



SUE PICTURE 49



SUE PICTURE 50



SUE PICTURE 51



SUE PICTURE 52



SUE PICTURE 53



SUE PICTURE 54



SUE PICTURE 55



SUE PICTURE 56



SUE PICTURE 57



SUE PICTURE 58



SUE PICTURE 59



SUE PICTURE 60



STEVEN AGAP, P.E.
LICENSE #8512
Tetra Tech Inc.
10600 Chevrolet Way, Ste. 102
Estero, Florida 33928
Engineering Business No. 2429

10600 CHEVROLET WAY, SUITE 102
ESTERO, FL 33928
PHONE: (239) 390-1487 FAX: (407) 839-3790
www.tetrattech.com

DATE

MARK	DATE	DESCRIPTION	BY

LEE COUNTY UTILITIES
CRYSTAL DRIVE
WATER MAIN IMPROVEMENTS
SOFT DIG PICTURES

Project No.: 200-01558-19001
Designed By: AS
Drawn By: WV
Checked By: AS

C-507

Copyright: Tetra Tech

Bar Measures 1 inch

7/15/2020 8:24:01 PM - O:\PROJECTS\ORLANDO\1550200-01558-19001\CAD\SHEETFILES\C-508 SUE PICTURES.DWG - CYR, STEVE

SUE PICTURE 61



SUE PICTURE 62



SUE PICTURE 63



SUE PICTURE 64



SUE PICTURE 65



SUE PICTURE 66



SUE PICTURE 67



SUE PICTURE 68



SUE PICTURE 69



SUE PICTURE 70



SUE PICTURE 71



SUE PICTURE 72



SUE PICTURE 73



SUE PICTURE 74



SUE PICTURE 75



SUE PICTURE 76



SUE PICTURE 77



SUE PICTURE 78



SUE PICTURE 79



SUE PICTURE 80



STEVEN AGAPI, P.E.
LICENSE #88612
Tetra Tech Inc.
10600 Chevrolet Way, Ste. 102
Estero, Florida 33928
Engineering Business No. 2429

10600 CHEVROLET WAY, SUITE 102
ESTERO, FL 33928
PHONE: (239) 390-1467 FAX: (407) 839-3790
www.tetrattech.com

DATE

MARK	DATE	DESCRIPTION	BY

LEE COUNTY UTILITIES
CRYSTAL DRIVE
WATER MAIN IMPROVEMENTS
SOFT DIG PICTURES

Project No.: 200-01558-19001
Designed By: AS
Drawn By: WV
Checked By: AS

C-508

Bar Measures 1 inch

Copyright: Tetra Tech

A photograph of a residential yard. In the foreground, there is a concrete walkway on the left and a green lawn. A small, orange, rectangular object, possibly a marker or a small structure, is visible on the lawn near the walkway. In the background, there is a large palm tree, some shrubs, and a blue pool or patio area. The scene is brightly lit, suggesting a sunny day.



A photograph of a residential yard. In the foreground, there is a concrete walkway on the left and a grassy area. A palm tree stands in the center, surrounded by a bed of reddish-brown mulch. In the background, a blue swimming pool is visible, bordered by a concrete wall and surrounded by trees and landscaping.



TETRA TECH

www.tetrattech.com

10600 CHEVROLET WAY, SUITE 102
ESTERO, FL 33928
PHONE: (239) 390-1467 FAX: (407) 839-3790

STEVEN AGAPI, P.E.
LICENSE #886612
Tetra Tech Inc.
10600 Chevrolet Way, Ste. 102
Estero, Florida 33928
Engineering Business No. 2429

DATE _____

[illegible]

LEE COUNTY UTILITIES
CRYSTAL DRIVE
WATER MAIN IMPROVEMENTS
SOFT DIG PICTURES

Project No.:	200-01558-1900
Designed By:	AS
Drawn By:	WV
Checked By:	AS

C-509

Copyright: Tetra Tech

7/15/2020 8:28:45 PM - O:\PROJECTS\ORLANDOVER\01558\200-01558-1\9001\CAD\SHEETFILES\C-510 SUE PICTURES.DWG - CYR, STEVE

SUE PICTURE 101



SUE PICTURE 102



SUE PICTURE 103



SUE PICTURE 104



SUE PICTURE 105



SUE PICTURE 106



SUE PICTURE 107



SUE PICTURE 108



SUE PICTURE 109



SUE PICTURE 110



SUE PICTURE 111



SUE PICTURE 112



SUE PICTURE 113



SUE PICTURE 114



SUE PICTURE 115



SUE PICTURE 116



SUE PICTURE 117



SUE PICTURE 118



SUE PICTURE 119



SUE PICTURE 120



STEVEN AGAPI, P.E.
LICENSE #88612
Tetra Tech Inc.
10600 Chevrolet Way, Ste. 102
Estero, Florida 33928
Engineering Business No. 2429

10600 CHEVROLET WAY, SUITE 102
ESTERO, FL 33928
PHONE: (239) 390-1467 FAX: (407) 838-3790

DATE

MARK	DATE	DESCRIPTION	BY

LEE COUNTY UTILITIES
CRYSTAL DRIVE
WATER MAIN IMPROVEMENTS
SOFT DIG PICTURES

Project No.: 200-01558-19001
Designed By: AS
Drawn By: WV
Checked By: AS

C-510

Copyright: Tetra Tech

Bar Measures 1 inch

7/15/2020 8:28:22 PM - O:\PROJECTS\ORLANDO\1558\200-01558-19001\CAD\SHEETFILES\C-511 SUE PICTURES.DWG - CYR, STEVE

SUE PICTURE 121



SUE PICTURE 122



SUE PICTURE 123



SUE PICTURE 124



SUE PICTURE 125



SUE PICTURE 126



SUE PICTURE 127



SUE PICTURE 128



SUE PICTURE 129



SUE PICTURE 130



SUE PICTURE 131



SUE PICTURE 132



SUE PICTURE 133



SUE PICTURE 134



SUE PICTURE 135



SUE PICTURE 136



SUE PICTURE 137



SUE PICTURE 138



SUE PICTURE 139



SUE PICTURE 140



LEE COUNTY UTILITIES
CRYSTAL DRIVE
WATER MAIN IMPROVEMENTS
SOFT DIG PICTURES

Project No.: 200-01558-19001
Designed By: AS
Drawn By: WV
Checked By: AS

C-511

Bar Measures 1 inch

TETRA TECH

STEVEN AGAPI, P.E.
LICENSE #68612
Tetra Tech Inc.
10600 Chevrolet Way, Ste. 102
Estero, Florida 33928
Engineering Business No. 2429

Copyright: Tetra Tech

10600 CHEVROLET WAY, SUITE 102
ESTERO, FL 33928
PHONE: (239) 390-1447 FAX: (407) 835-3750

DATE

SUE PICTURE 145



SUE PICTURE 150



SUE PICTURE 155



SUE PICTURE 160



10600 CHEVROLET WAY, SUITE 102
ESTERO, FL 33928
PHONE: (239) 390-1467 FAX: (407) 839-3790
www.tetrattech.com

1

[illegible]

Project No.:	200-01558-19001
Designed By:	AS
Drawn By:	WV
Checked By:	AS

C-512

Measures 1 inch

7/15/2020 8:31:18 PM - C:\PROJECTS\ORLANDO\1558\200-01558-19001\CAD\SHEET\FILES\C-513 SUE PICTURES.DWG - CYR, STEVE

SUE PICTURE 161



SUE PICTURE 162



SUE PICTURE 163



SUE PICTURE 164



SUE PICTURE 165



SUE PICTURE 166



SUE PICTURE 167



SUE PICTURE 168



SUE PICTURE 169



SUE PICTURE 170



SUE PICTURE 171



SUE PICTURE 172



SUE PICTURE 173



SUE PICTURE 174



SUE PICTURE 175



SUE PICTURE 176



SUE PICTURE 177



STEVEN AGAPI, P.E.
LICENSE #88612
Tetra Tech Inc.
10600 Chevrolet Way, Ste. 102
Estero, Florida 33928
Engineering Business No. 2429

10600 CHEVROLET WAY, SUITE 102
ESTERO, FL 33928
PHONE: (239) 390-1467 FAX: (407) 839-3790

DATE

MARK	DATE	DESCRIPTION	BY

LEE COUNTY UTILITIES
CRYSTAL DRIVE
WATER MAIN IMPROVEMENTS
SOFT DIG PICTURES

Project No.: 200-01558-19001
Designed By: AS
Drawn By: WW
Checked By: AS

C-513

Bar Measures 1 Inch

Copyright: Tetra Tech